


ELECTRICAL DRAWINGS  
FOR  
SCHOOL & SKILL CENTER  
AT BAIKER BALOCHISTAN

CLIENT :  
TAALEEM FOUNDATION.

DATE : 02-NOV-2025

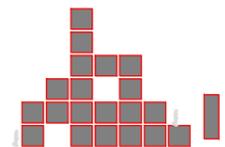

**TETR S**  
Design Studio

Phone: 03379225835  
Email: tetrisdesignstudio11@gmail.com

**CONSULTANTS :**



Phone: 03379225835  
Email:tetrisdesignstudio11@gmail.com

**LEGEND:**

DESCRIPTION	MOUNTING HEIGHT BOTTOM FROM FFL	SYMBOL
SWITCH BOARD	4'-0"	
2 WAY SWITCH POINT	4'-0"	
HALOGEN SPOT LIGHT	CEILING	
EXHAUST FAN	8'-0"	
WALL LED LIGHT	7'-0"	
DECORATED LIGHT	CEILING	
FAN POINT	CEILING / 9'-0"	
MIRROR LIGHT	7'-0"	
BRACKET FAN	7'-0"	
IDUN LIGHT	CEILING	
DISTRIBUTION BOARD	4'-0"	
ELECTRIC BELL	7'-0"	
40W LED TUBE LIGHT	CEILING / HANGING	
LIGHT PLUG 5A/10A	1'-0"	
WATER PROOF POWER PLUG	1'-0"	

DESCRIPTION	MOUNTING HEIGHT BOTTOM FROM FFL	SYMBOL
FLOOR MOUNTED LIGHT WATER PROOF POLE LIGHT	Floor Mounted	
MULTI PLUG	1'-0"	
POWER PLUG (GEYSER)	1'-0"	
POWER PLUG (AC)	7'-0"	
JUNCTION BOX	WALL	
TELE PHONE (RJ-45) & TV POINT (RG-6)	1'-0"	
NETWORK VIDEO RECORDER	1'-0"	
CCTV CAMERA	CEILING	
WIRELESS FIDELITY	WALL / CEILING	
INTERCOM (Kitchen)	4'-0"	
FANCY LIGHTS MAIN GATE LIGHT	Column main gate	
WATER PROOF LIGHT	WALL	
BELL PUSH BUTTON	4'-0"	
ELECTRIC METER	4'-0"	
EARTHING SYMBOL		

**ELECTRICAL NOTES:**

- 01-The contractor shall thoroughly review all the drawings before start of work and shall coordinate with all other discipline and any discrepancy appears it should be brought to the consultant's knowledge immediately, before start work.
- 02-No work shall be carried out unless shop drawing are prepared and Submitted by the contractor for the approval of consultant.
- 03-MEP services shall not cut in any structural beams, ribs or any other structural elements unless a prior written approval has been taken from the Structure Engineer.
- 04-MEP contractor shall provide sleeve/opening/pipes in civil work prior to Construction for respective services.
- 05-Provide earth pits as indicated in the drawings, it details to be coordinated with other discipline.
- 06-All electrical operated equipment shall have earth connections.
- 07-Minimum wire size shall be 1.5mm.sq for detail cable sizes see DB details given in the drawings.
- 08-Contractor shall take approval from consultant for all the material to be installed prior to purchase however, Pakistan cable, New age and Pioneer Cable are approved.
- 09-All distributions board DB, s shall be approved by consultant prior to purchase by Contractor, Contractor provide technical submittal for DB,s.
- 10-Main and sub Telephone/TV/FACP junctions' box shall be provided where required.
- 11-All kinds of wiring shall not be visible inside or outside the Building, contractor shall place sleeve/conduits where required during constructions.
- 12-Color coding for wires shall be done and approved by IEEE regulations.
- 13-The distance for cables supports and saddle for conduit or cable tray shall be according to the latest IEEE regulations.
- 14-Use separate conduit for every circuit coming out of DBs and provide Junction box required for easy pulling electrical wire.
- 15-Fire alarm panel digital video recorder, voice control panel shall be under surveillance of security staff.
- 16-All electrical pumps motor shall be provide with starter relay.
- 17-lights layout schematic, selections of lights shall be done by the architect.
- 18-Telephone & Networking cables must be 1ft away from POWER & NETWORKING cable.

PROJECT:  
SCHOOL & SKILL CENTER  
AT  
BAIKER BALOCHISTAN.

CLIENT:  
TAALEEM FOUNDATION

TITLE:  
ELECTRICAL LEGENDS &  
ELECTRICAL GENERAL NOTES

DRAWN BY:  
FARMAN ULLAH

CHECKED BY:  
Ar. FARUKH RAZZAQ

SCALE:  
N. T. S.


DRAWING NO. E-01

DATE: NOV- 2025

CONSULTANTS :



Phone: 03379225835  
Email: tetrisdesignstudio11@gmail.com

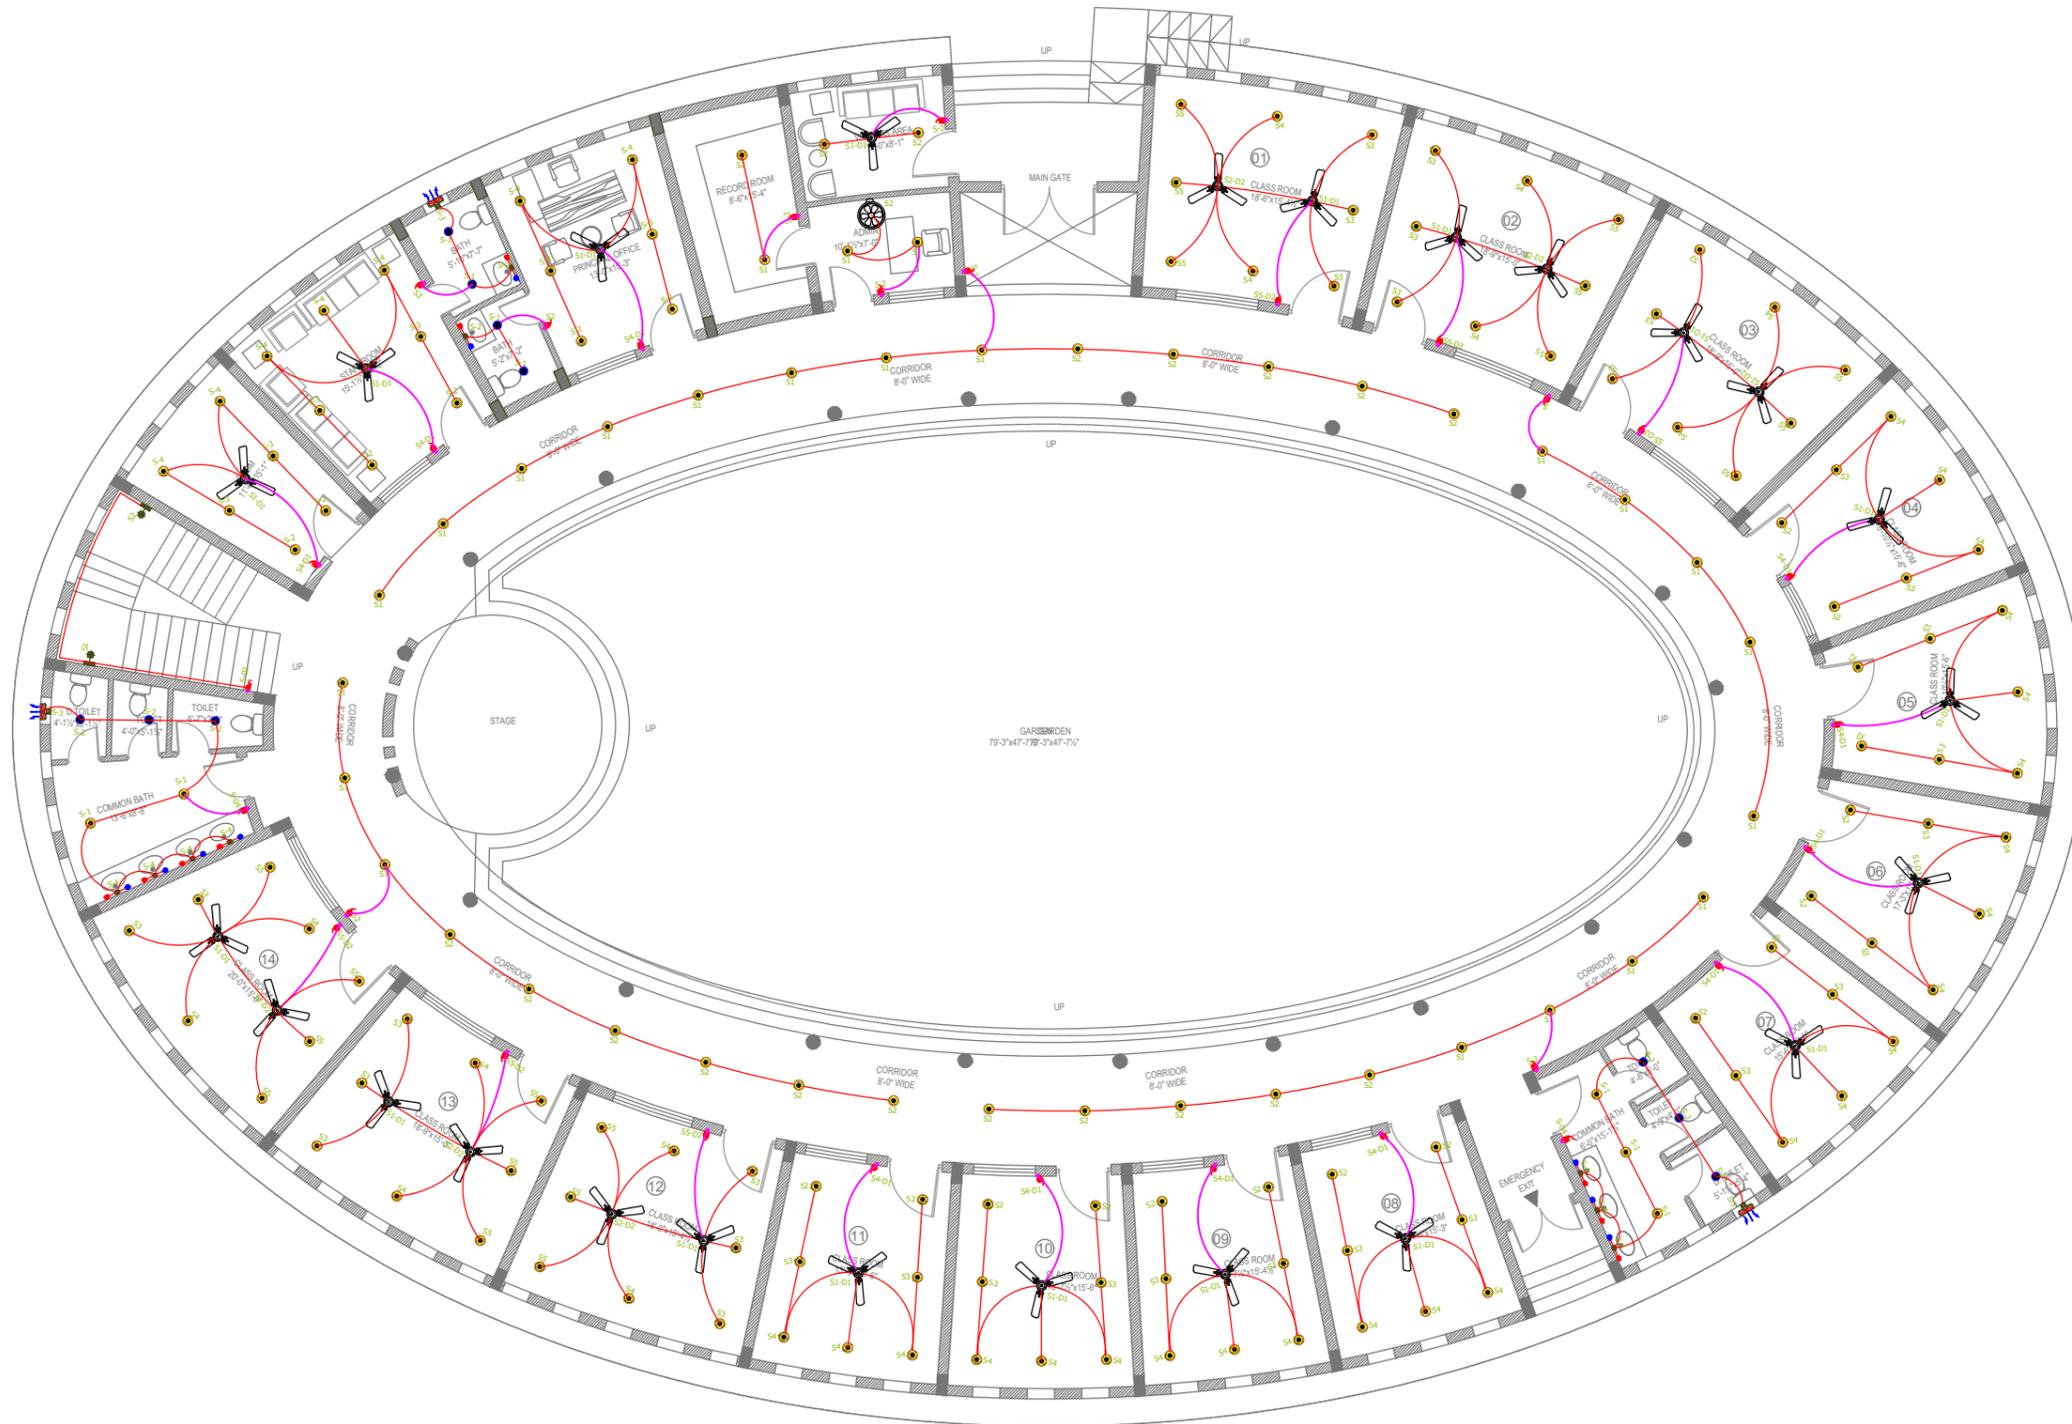

GROUND FLOOR FURNITURE LAYOUT PLAN

PROJECT:  
SCHOOL & SKILL CENTER  
AT  
BAIKER BALOCHISTAN.

CLIENT:  
TAALEEM FOUNDATION

TITLE:  
LIGHTING LAYOUT PLAN

DRAWN BY:  
FARMAN ULLAH

CHECKED BY:  
Ar. FARUKH RAZZAQ

SCALE:  
N. T. S.


DRAWING NO. E-02

DATE: NOV- 2025

CONSULTANTS :



Phone: 03379225835  
Email: tetrisdesignstudio11@gmail.com

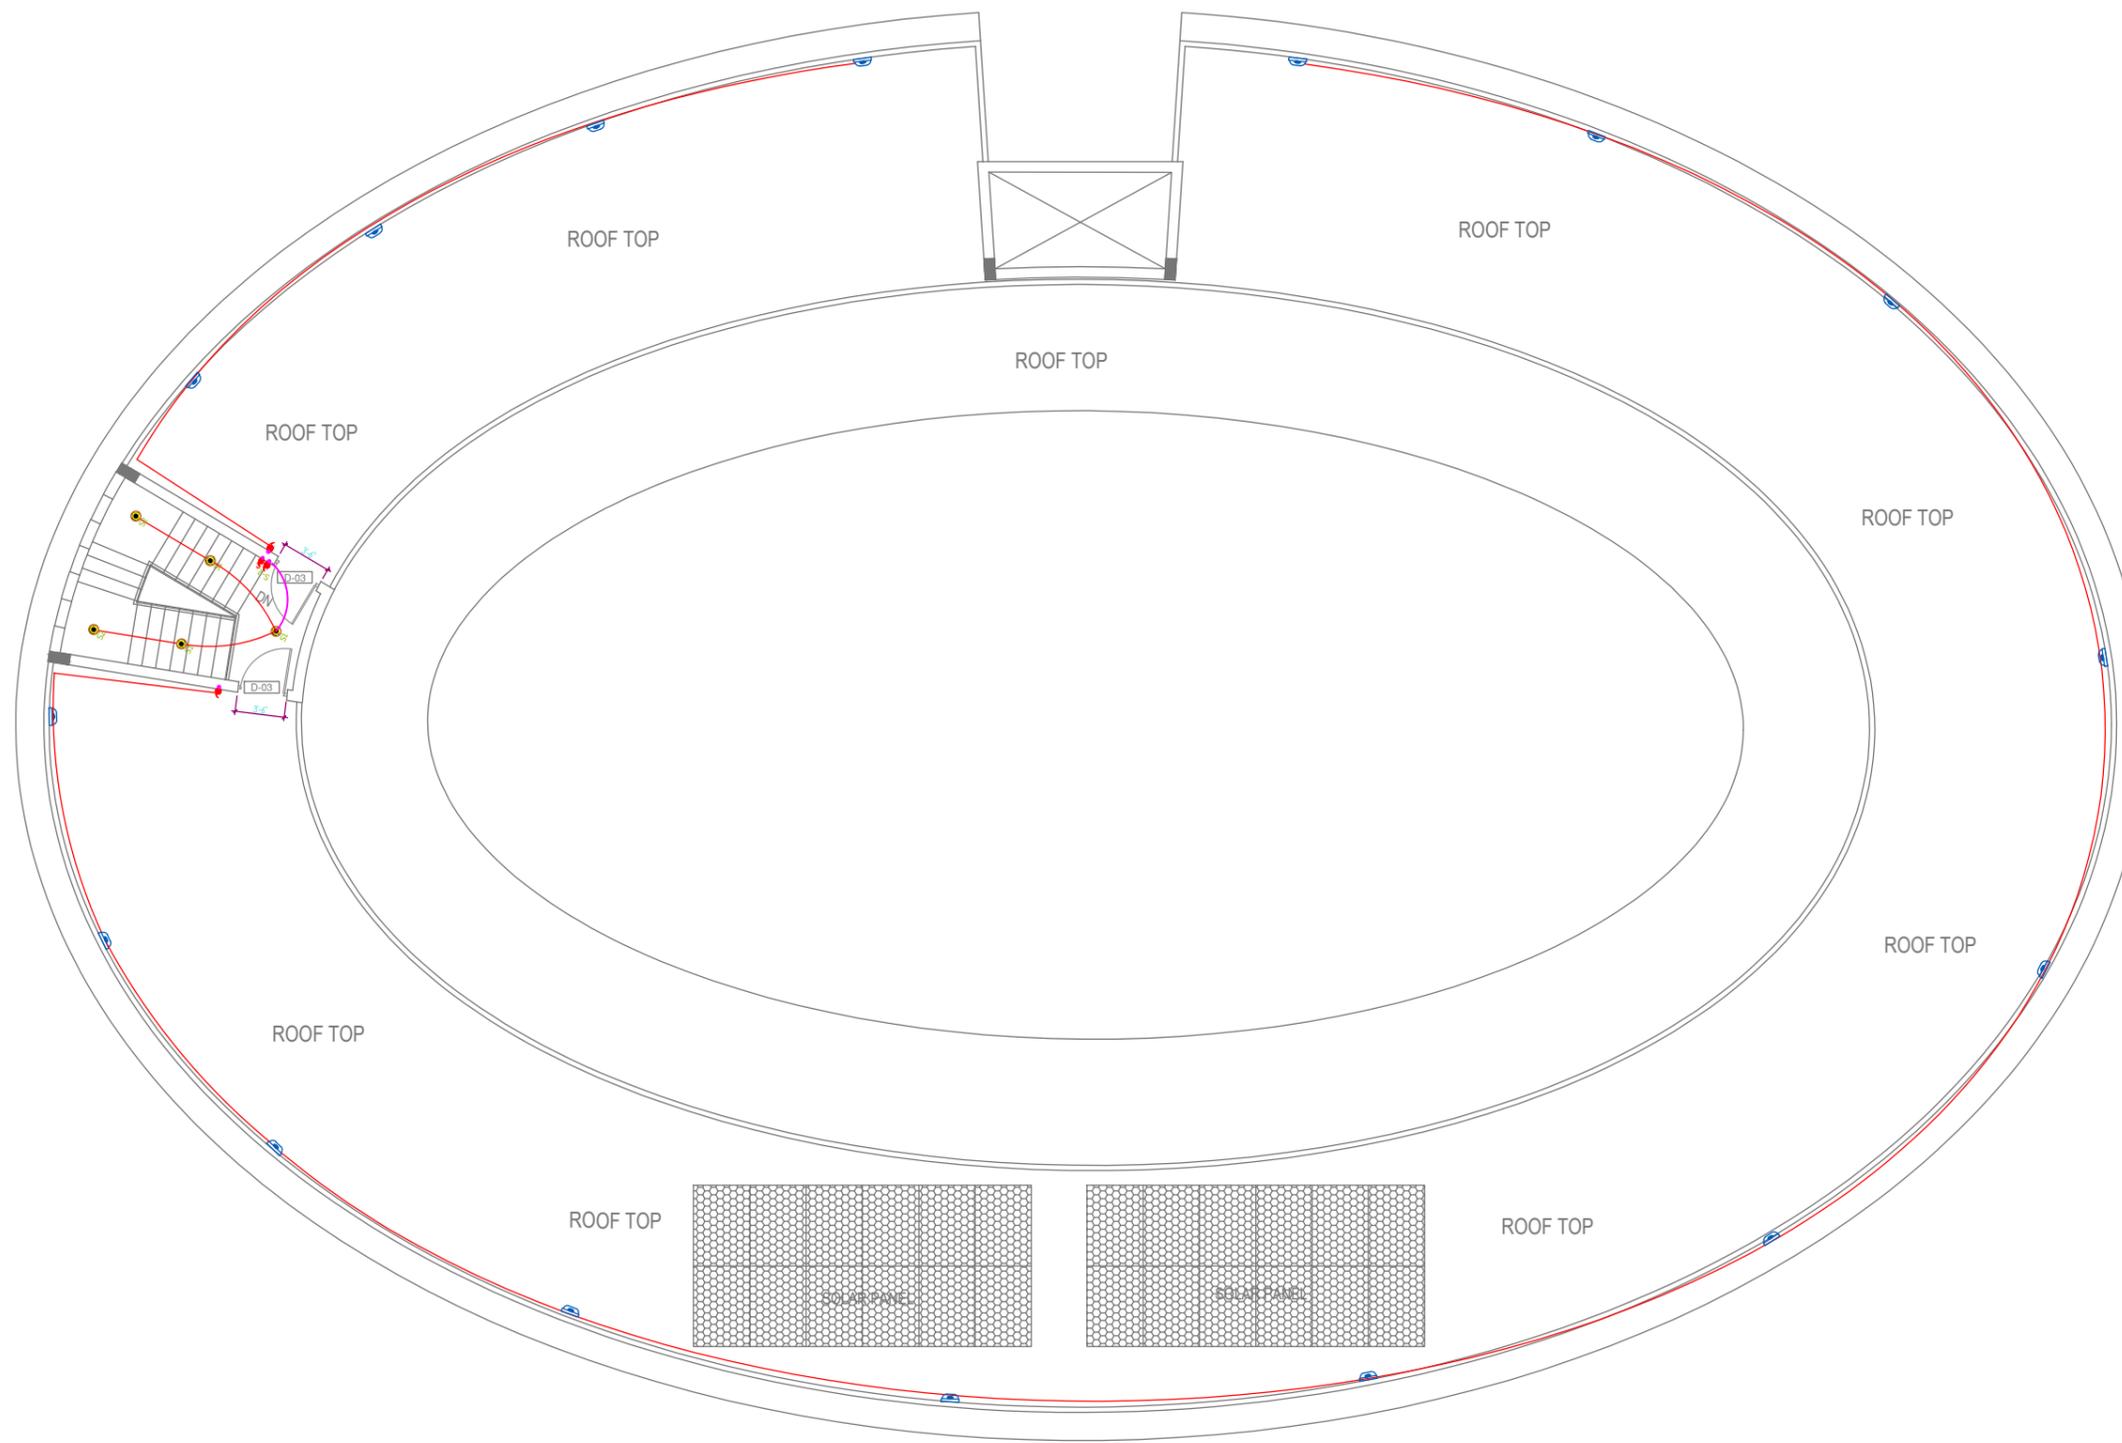

MUMTY FLOOR PLAN

PROJECT:

SCHOOL & SKILL CENTER  
AT  
BAIKER BALOCHISTAN.

CLIENT:

TAALEEM FOUNDATION

TITLE:

LIGHTING LAYOUT PLAN

DRAWN BY:

FARMAN ULLAH

CHECKED BY:

Ar. FARUKH RAZZAQ

SCALE:

N. T. S.


DRAWING NO. E-03

DATE: NOV- 2025

CONSULTANTS :



Phone: 03379225835  
Email: tetrisdesignstudio11@gmail.com

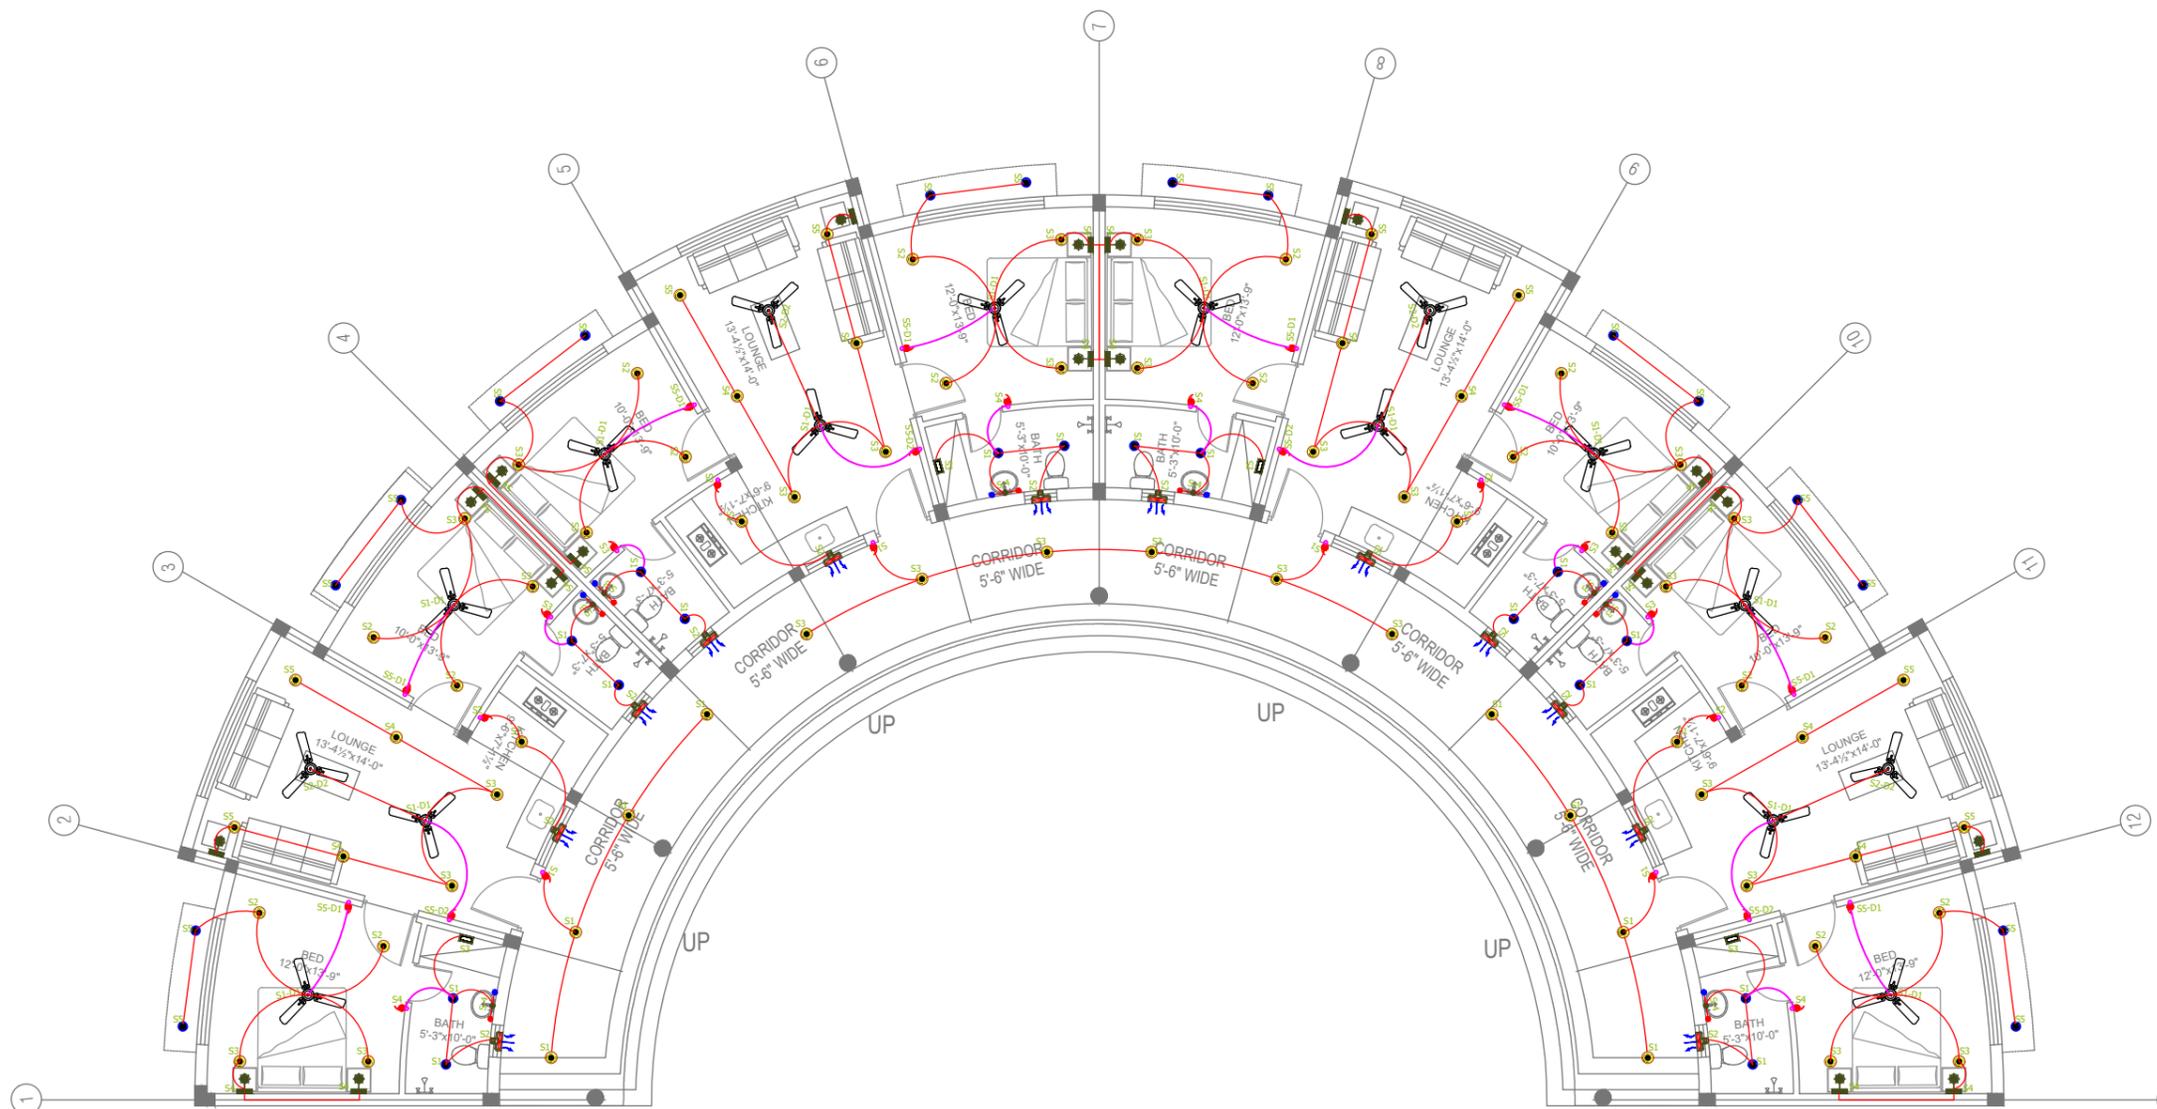

STAFF RESIDENCE  
GROUND FLOOR PLAN

PROJECT:

SCHOOL & SKILL CENTER  
AT  
BAIKER BALOCHISTAN.

CLIENT:

TAALEEM FOUNDATION

TITLE:

LIGHTING LAYOUT PLAN

DRAWN BY:

FARMAN ULLAH

CHECKED BY:

Ar. FARUKH RAZZAQ

SCALE:

N. T. S.

DRAWING NO.

E-04

DATE:

NOV- 2025

CONSULTANTS :



Phone: 03379225835  
Email: tetrisdesignstudio11@gmail.com

PROJECT:

SCHOOL & SKILL CENTER  
AT  
BAIKER BALOCHISTAN.

CLIENT:

TAALEEM FOUNDATION

TITLE:

POWER LAYOUT PLAN

DRAWN BY:

FARMAN ULLAH

CHECKED BY:

Ar. FARUKH RAZZAQ

SCALE:


N. T. S.

DRAWING NO.

E-05

DATE:

NOV- 2025

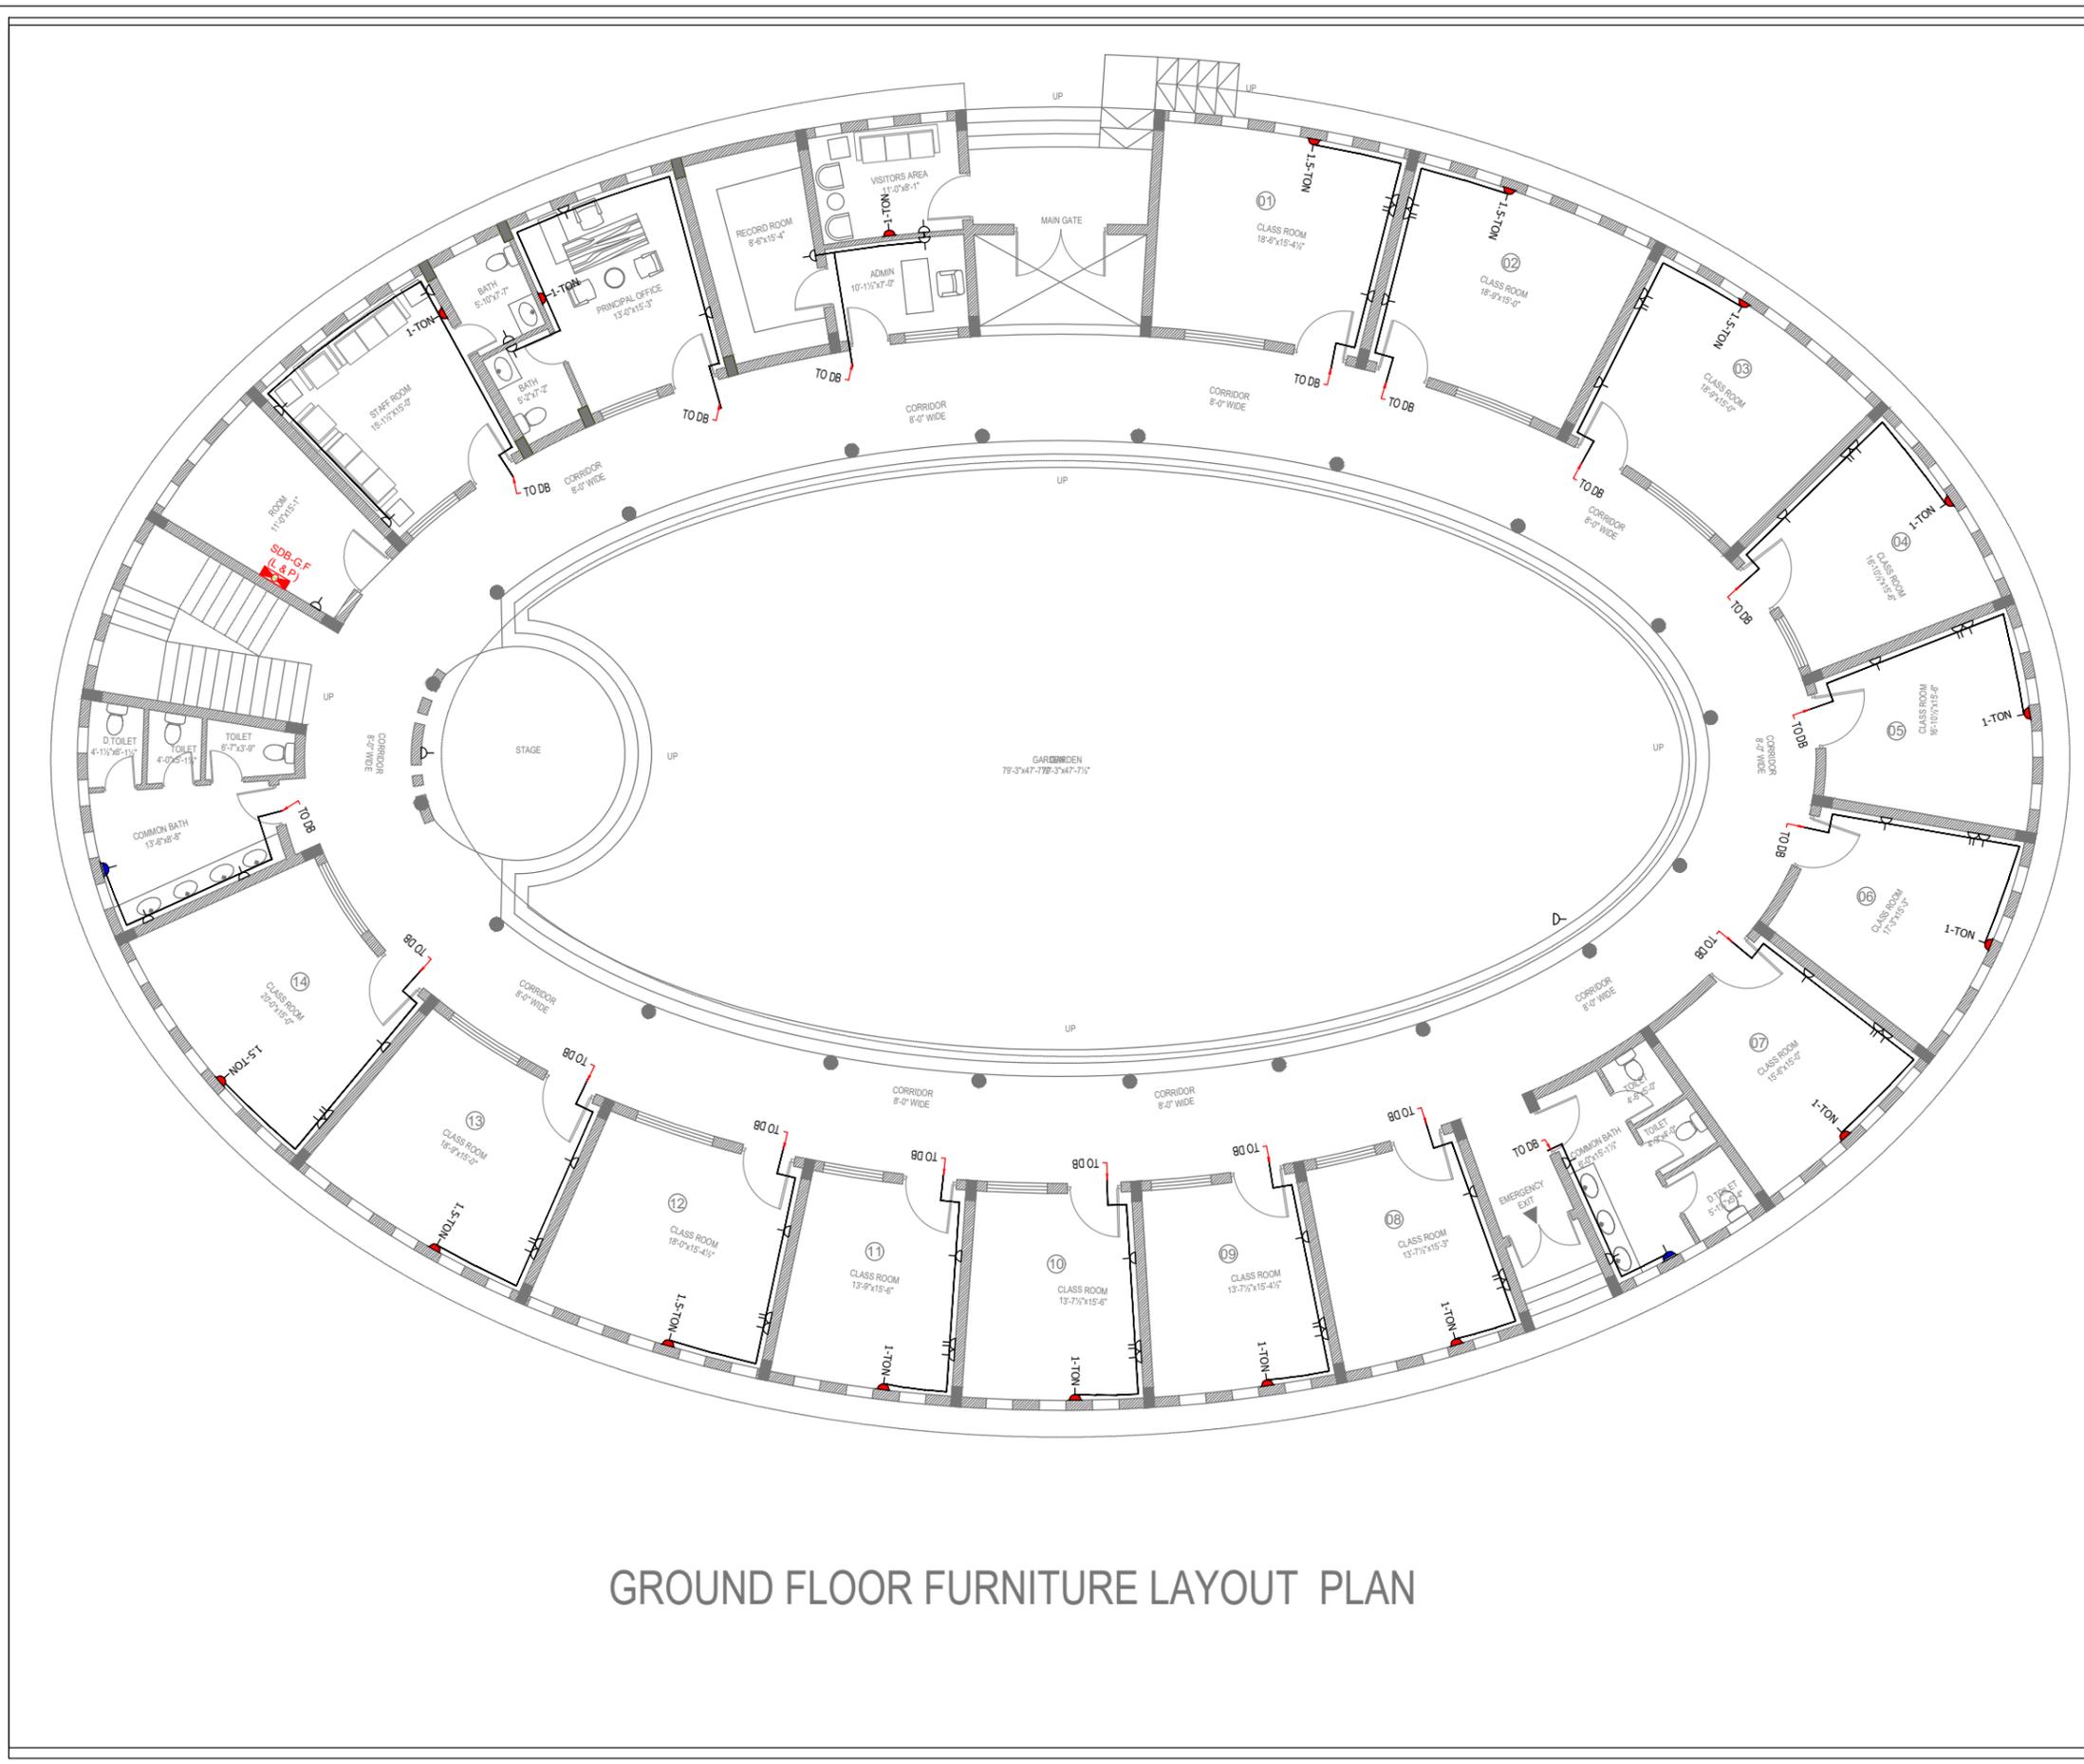


GROUND FLOOR FURNITURE LAYOUT PLAN

CONSULTANTS :



Phone: 03379225835  
Email: tetrisdesignstudio11@gmail.com

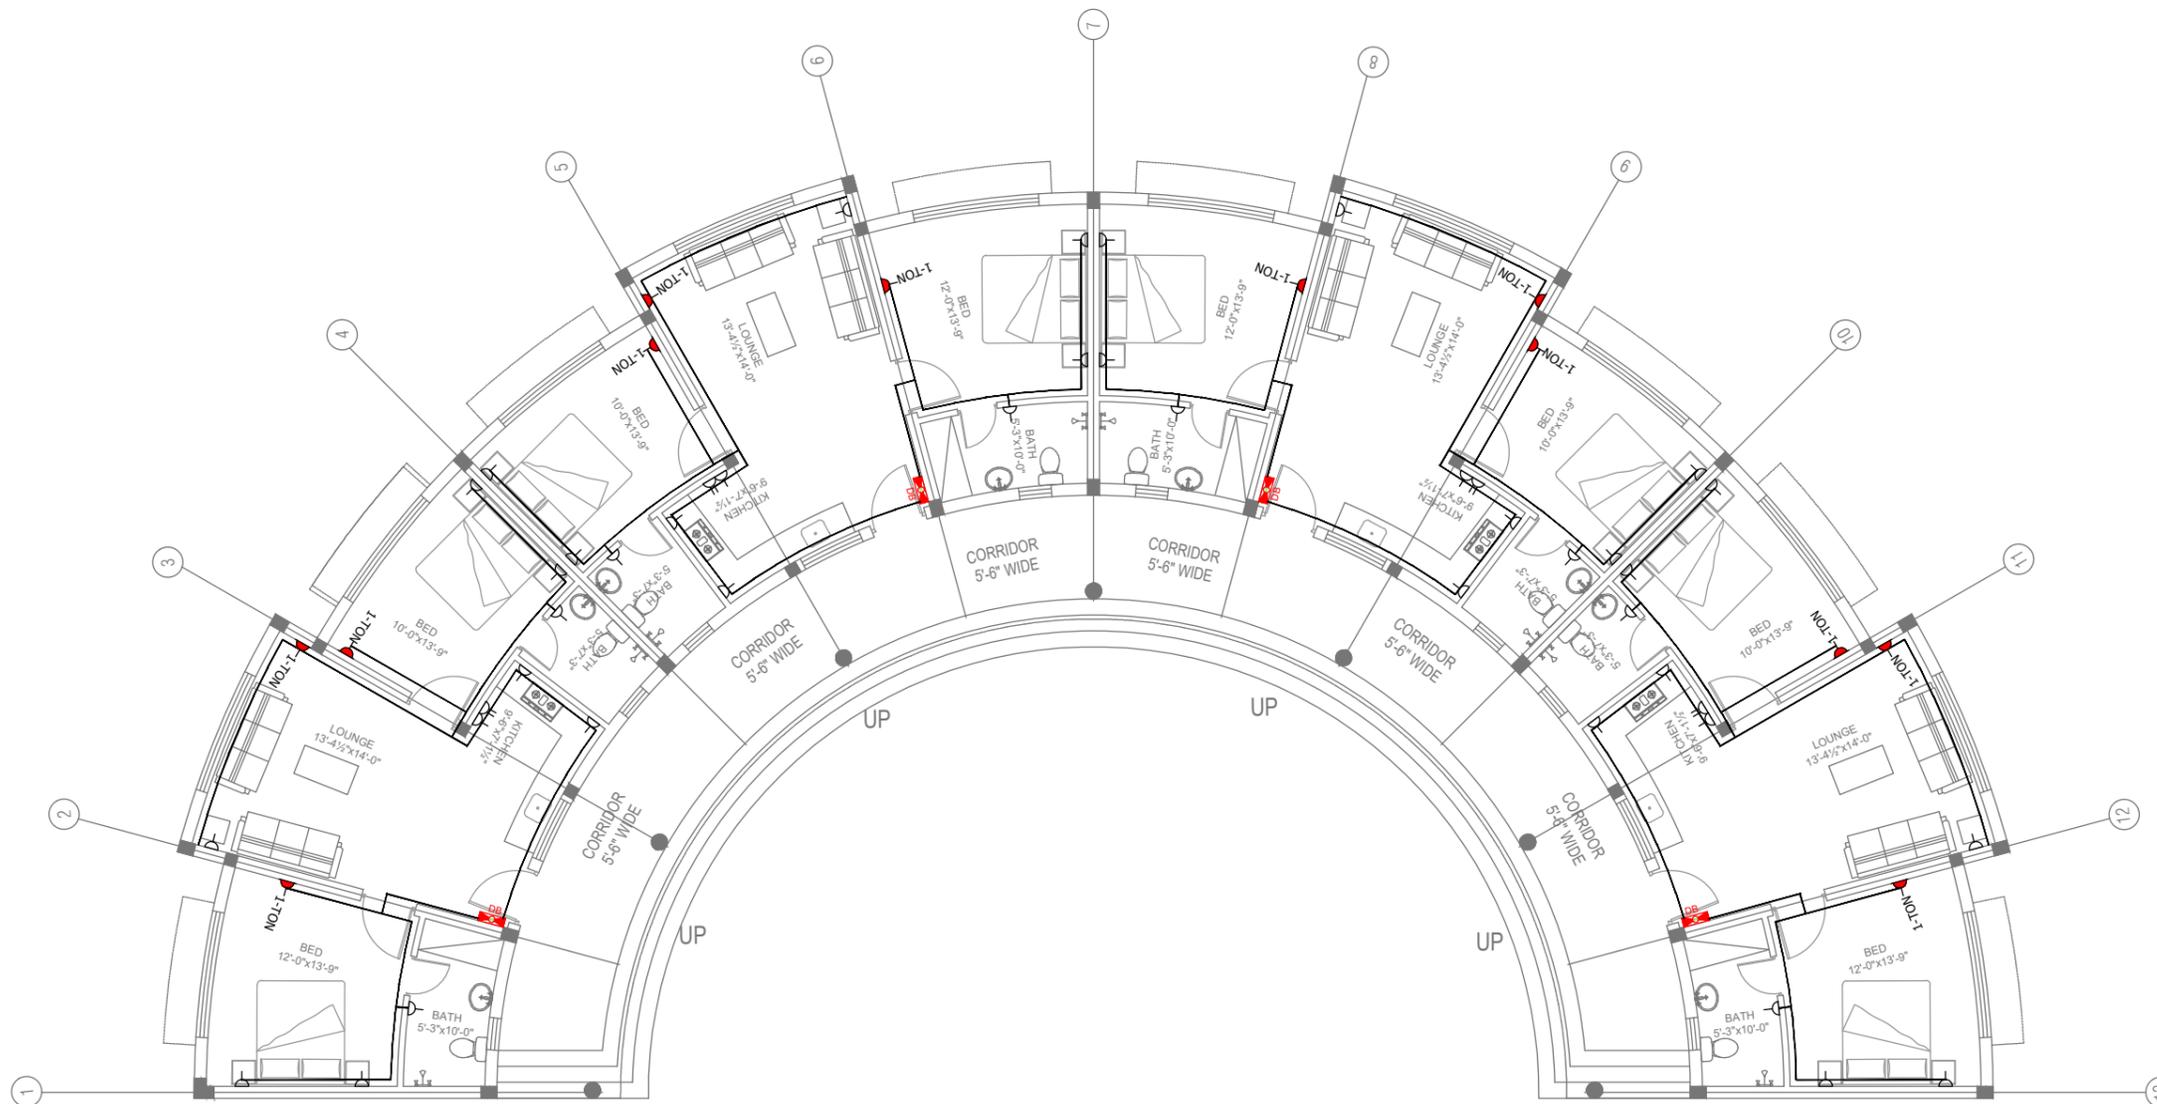

STAFF RESIDENCE  
GROUND FLOOR PLAN

PROJECT:

SCHOOL & SKILL CENTER  
AT  
BAIKER BALOCHISTAN.

CLIENT:

TAALEEM FOUNDATION

TITLE:

POWER LAYOUT PLAN

DRAWN BY:

FARMAN ULLAH

CHECKED BY:

Ar. FARUKH RAZZAQ

SCALE:

N. T. S.

DRAWING NO.

E-06


DATE:

NOV- 2025

CONSULTANTS :



Phone: 03379225835  
Email: tetrisdesignstudio11@gmail.com

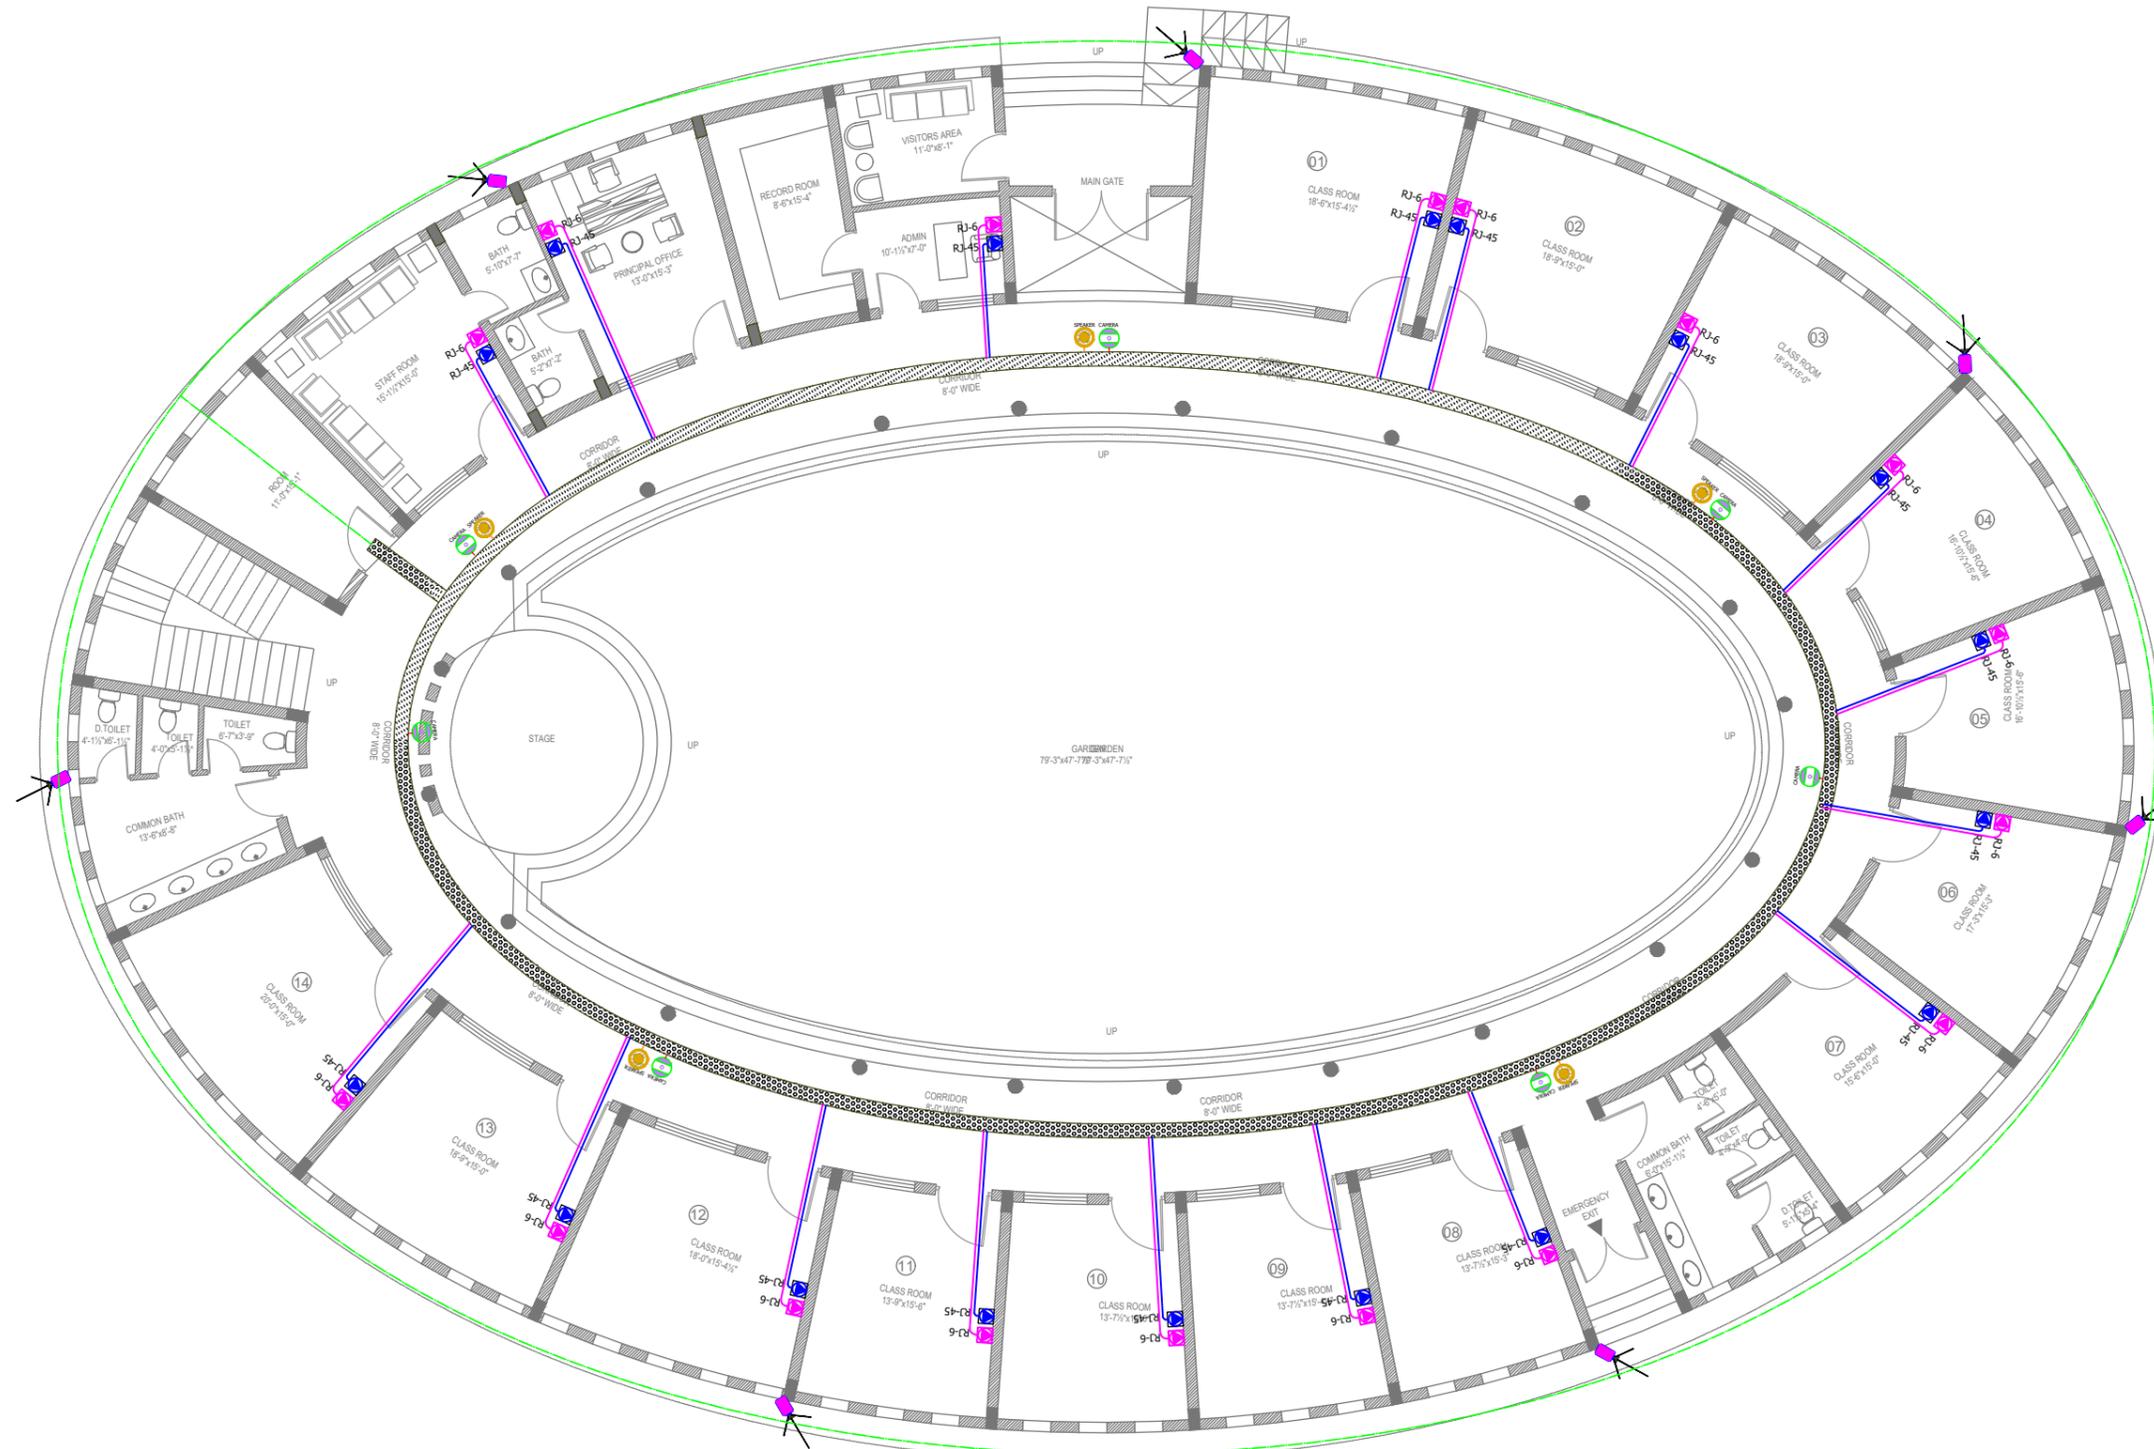

GROUND FLOOR FURNITURE LAYOUT PLAN

PROJECT:

SCHOOL & SKILL CENTER  
AT  
BAIKER BALOCHISTAN.

CLIENT:

TAALEEM FOUNDATION

TITLE:

ELV LAYOUT PLAN

DRAWN BY:

FARMAN ULLAH

CHECKED BY:

Ar. FARUKH RAZZAQ

SCALE:

N. T. S.

DRAWING NO.

E-07


DATE:

NOV- 2025

CONSULTANTS :



Phone: 03379225835  
Email: tetrisdesignstudio11@gmail.com

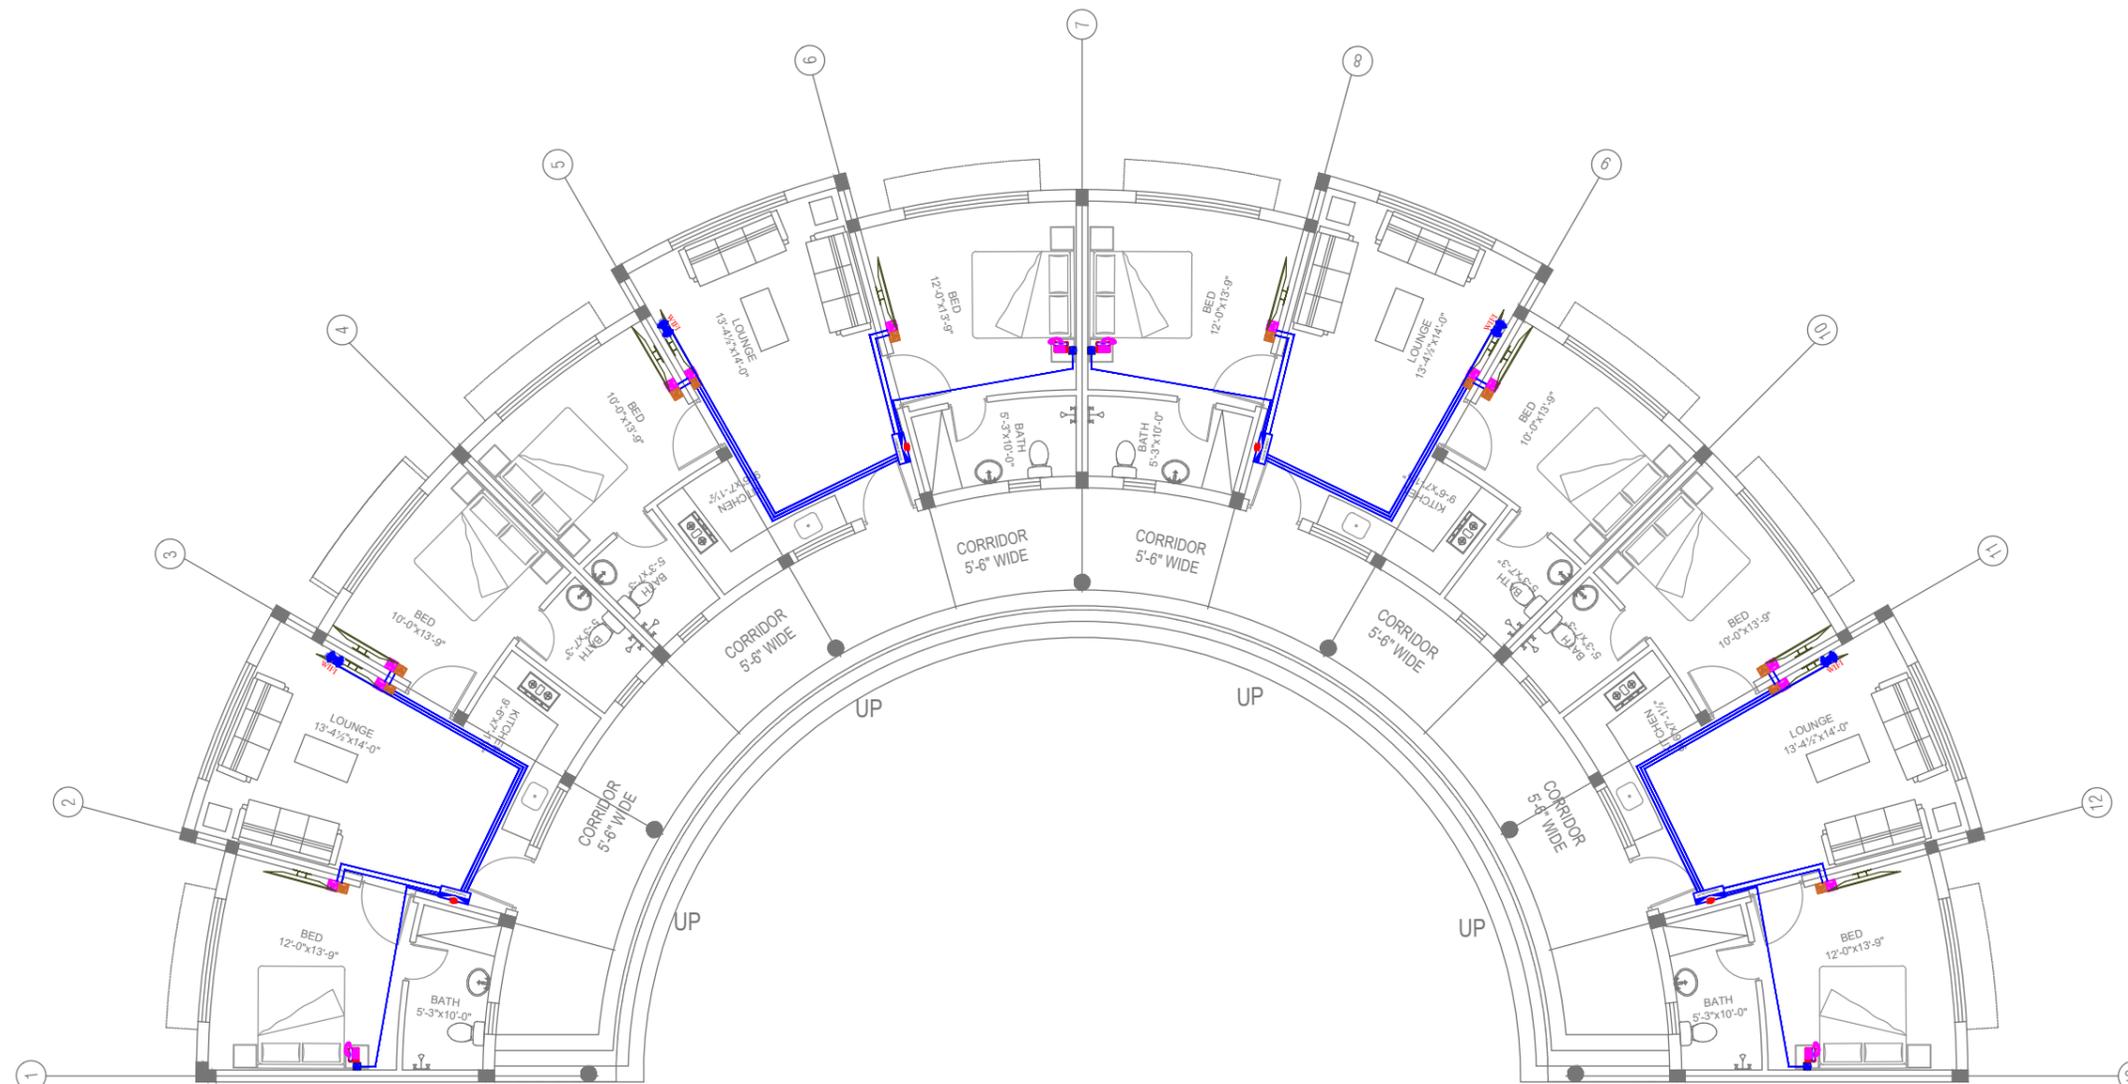

STAFF RESIDENCE  
GROUND FLOOR PLAN

PROJECT:

SCHOOL & SKILL CENTER  
AT  
BAIKER BALOCHISTAN.

CLIENT:

TAALEEM FOUNDATION

TITLE:

ELV LAYOUT PLAN

DRAWN BY:

FARMAN ULLAH

CHECKED BY:

Ar. FARUKH RAZZAQ

SCALE:

N. T. S.

DRAWING NO.

E-08

DATE:

NOV- 2025

CONSULTANTS :



Phone: 03379225835  
Email:tetrisdesignstudio11@gmail.com

PROJECT:

SCHOOL & SKILL CENTER  
AT  
BAIKER BALOCHISTAN.

CLIENT:

TAALEEM FOUNDATION

TITLE:

MASTER PLAN POLE LIGHTS PLAN

DRAWN BY:

FARMAN ULLAH

CHECKED BY:

Ar. FARUKH RAZZAQ

SCALE:


N. T. S.

DRAWING NO.

E-09

DATE:


NOV- 2025

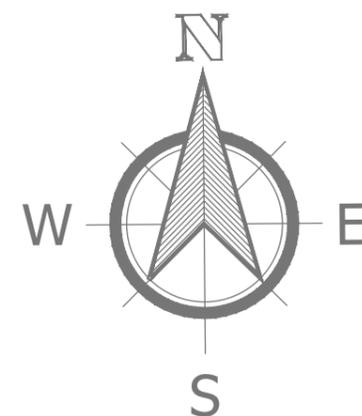

CONSULTANTS :



Phone: 03379225835  
Email: tetrdesignstudio11@gmail.com

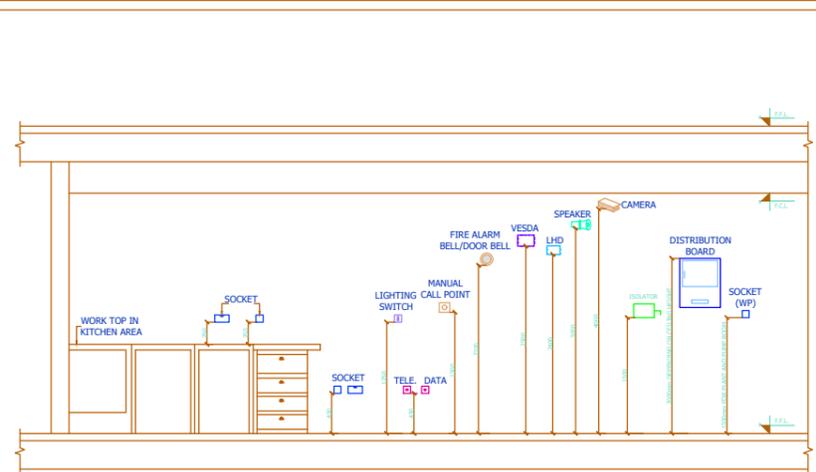

**STANDARD MOUNTING HEIGHT OF ELECTRICAL ACCESSORIES**




**WARNING SIGNS**

THIS SHALL BE FITTED WHERE MULTI GANG LIGHTING SWITCHES OR TWO LIGHTING SWITCHES ON DIFFERENT PHASES ARE CLOSER THAN ARMS REACH IN CONJUNCTION WITH SAFETY SIGN SHOWN IN FIG. 1. IT MUST BE AFFIXED ADJACENT SO THAT IT IS CLEARLY VISIBLE.




\* 380 OR 415V AS APPROPRIATE  
NOTES:-  
1. ALL DIMENSIONS ARE IN mm.

**WARNING SIGNS**

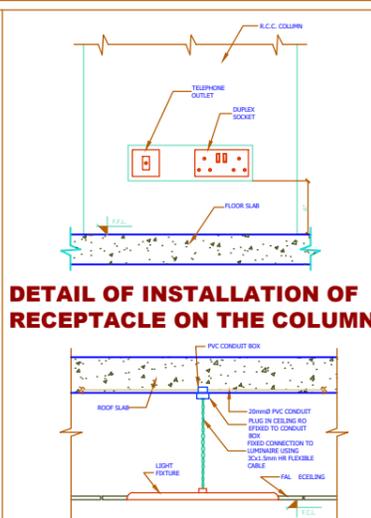


**DETAIL OF INSTALLATION OF RECEPTACLE ON THE COLUMN**

**LIGHT FIXTURE INSTALLATION DETAIL**

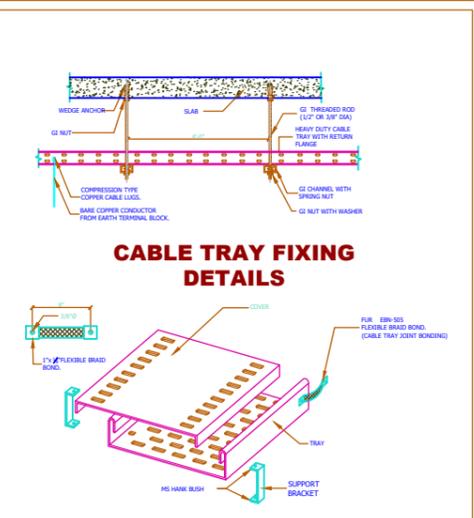


**CABLE TRAY FIXING DETAILS**


**CABLE TRAY DETAILS**

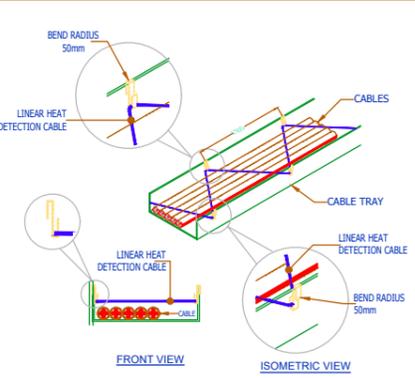


**LINEAR HEAT DETECTION CABLE IN CABLE TRAY**

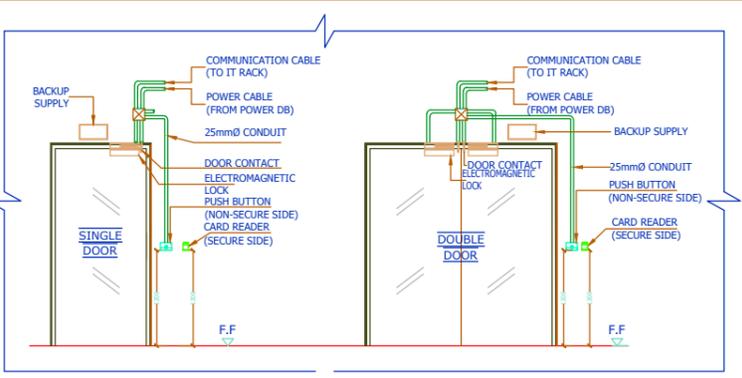

**ACCESS CONTROL PANEL DETAIL**

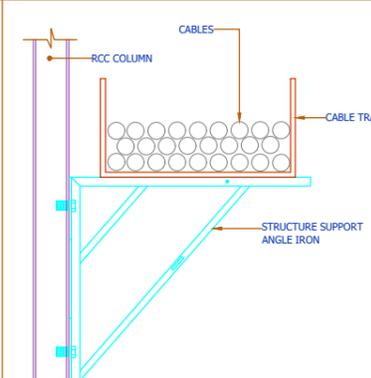

**CABLE TRAY SUPPORTS FROM WALL/COLUMN**

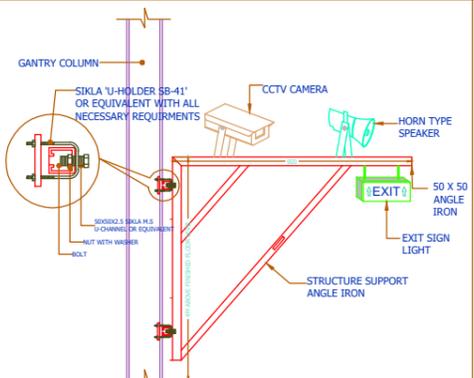

**SUPPORT FOR EQUIPMENT MOUNTED ON GANTRY STRUCTURE**

PROJECT:

SCHOOL & SKILL CENTER AT BAIKER BALOCHISTAN.

CLIENT:

TAALEEM FOUNDATION

TITLE:

CONSTRUCTION DETAIL-I

DRAWN BY:

FARMAN ULLAH

CHECKED BY:

Ar. FARUKH RAZZAQ

SCALE:


N. T. S.

DRAWING NO.


E-10

DATE:


NOV- 2025

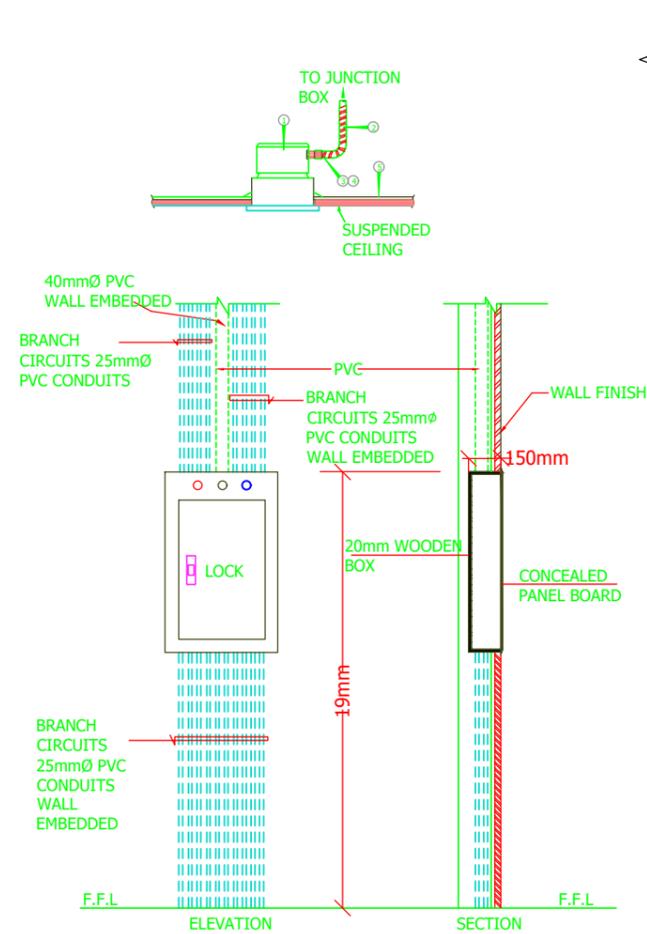

**TYPICAL PANEL BOARD INSTALLATION DETAILS**  
SCALE : N.T.S

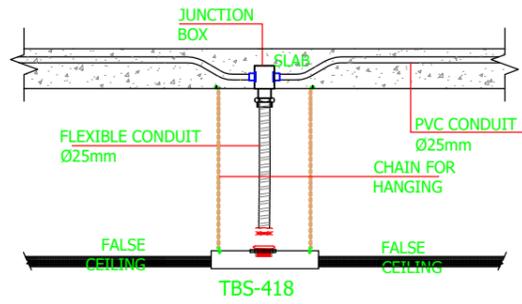

 
**FALSE CEILING LIGHTING DETAIL**  
SCALE : N.T.S




**GENERAL DETAIL FOR SOCKETS**  
SCALE : N.T.S



**LIGHTING INSTALLATION DETAIL**  
SCALE : N.T.S (CONCEALED)

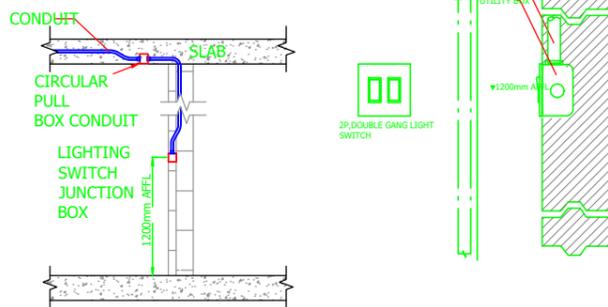

**LIGHTING SWITCH INSTALLATION DETAIL**  
SCALE : N.T.S

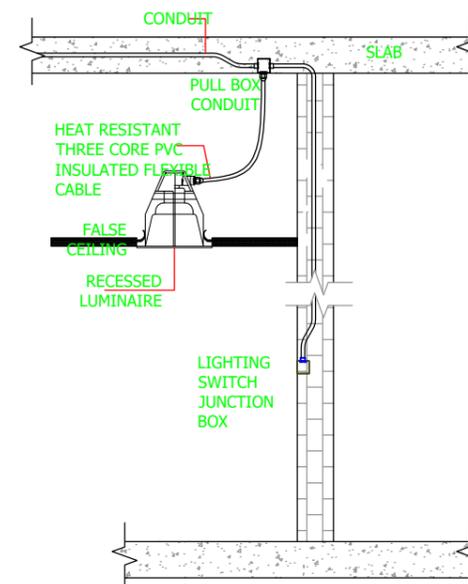

CONSULTANTS :



Phone: 03379225835  
Email: tetrisdesignstudio11@gmail.com

PROJECT:

SCHOOL & SKILL CENTER  
AT  
BAIKER BALOCHISTAN.

CLIENT:

TAALEEM FOUNDATION

TITLE:

CONSTRUCTION DETAIL-II

DRAWN BY:

FARMAN ULLAH

CHECKED BY:

Ar. FARUKH RAZZAQ

SCALE:

N. T. S.

DRAWING NO.

E-11



DATE:

NOV- 2025

CONSULTANTS :



Phone: 03379225835  
Email: tetrisdesignstudio11@gmail.com

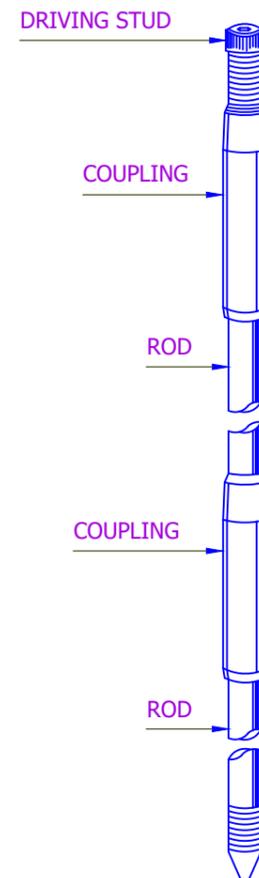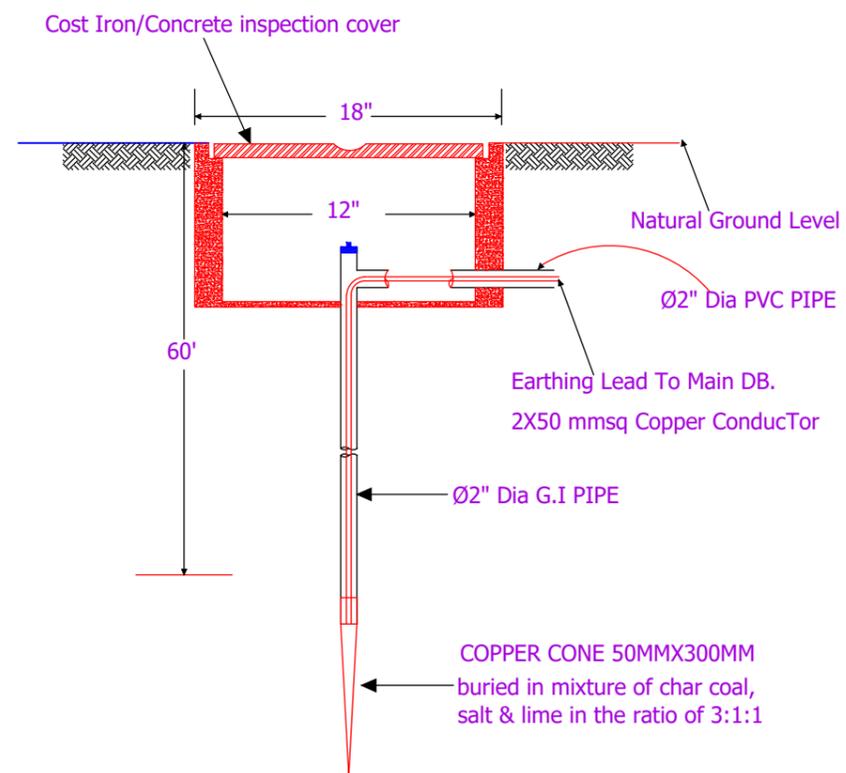

**NOTES FOR EARTHING SYSTEM**

- 1- EARTH BORE SHALL BE MADE AT 6'-0" AWAY FROM FOUNDATION.
- 2- DISTANCE BETWEEN 2 EARTH BORES SHALL NOT BE LESS THEN 10 ft (3m)
- 3- COPPER CONDUCTOR AT TOP OF G.I PIPE SHALL BE BOLTED WITH THIMBLES, BRASS NUTS, BOLTS ETC.
- 4- JOINTS SHALL BE COVERED WITH BITUMEN
- 5- CONTRACTOR TO MEASURE EARTHING RESISTANCE IN THE PRESENCE OF SITE ENGINEER. BOTH THE SITE ENGINEER AND CONTRACTOR SHALL SIGN THE EARTH TESTING RESULT AND SUBMIT IT TO THE CLIENT FOR RECORD.

PROJECT:  
SCHOOL & SKILL CENTER  
AT  
BAIKER BALOCHISTAN.

CLIENT:  
TAALEEM FOUNDATION

TITLE:  
CONSTRUCTION DETAIL-III  
EARTHING DETAIL

DRAWN BY:  
FARMAN ULLAH

CHECKED BY:  
Ar. FARUKH RAZZAQ

SCALE:  
N. T. S.


DRAWING NO. E-12

DATE: NOV- 2025

CONSULTANTS :



Phone: 03379225835  
Email: tetrisdesignstudio11@gmail.com

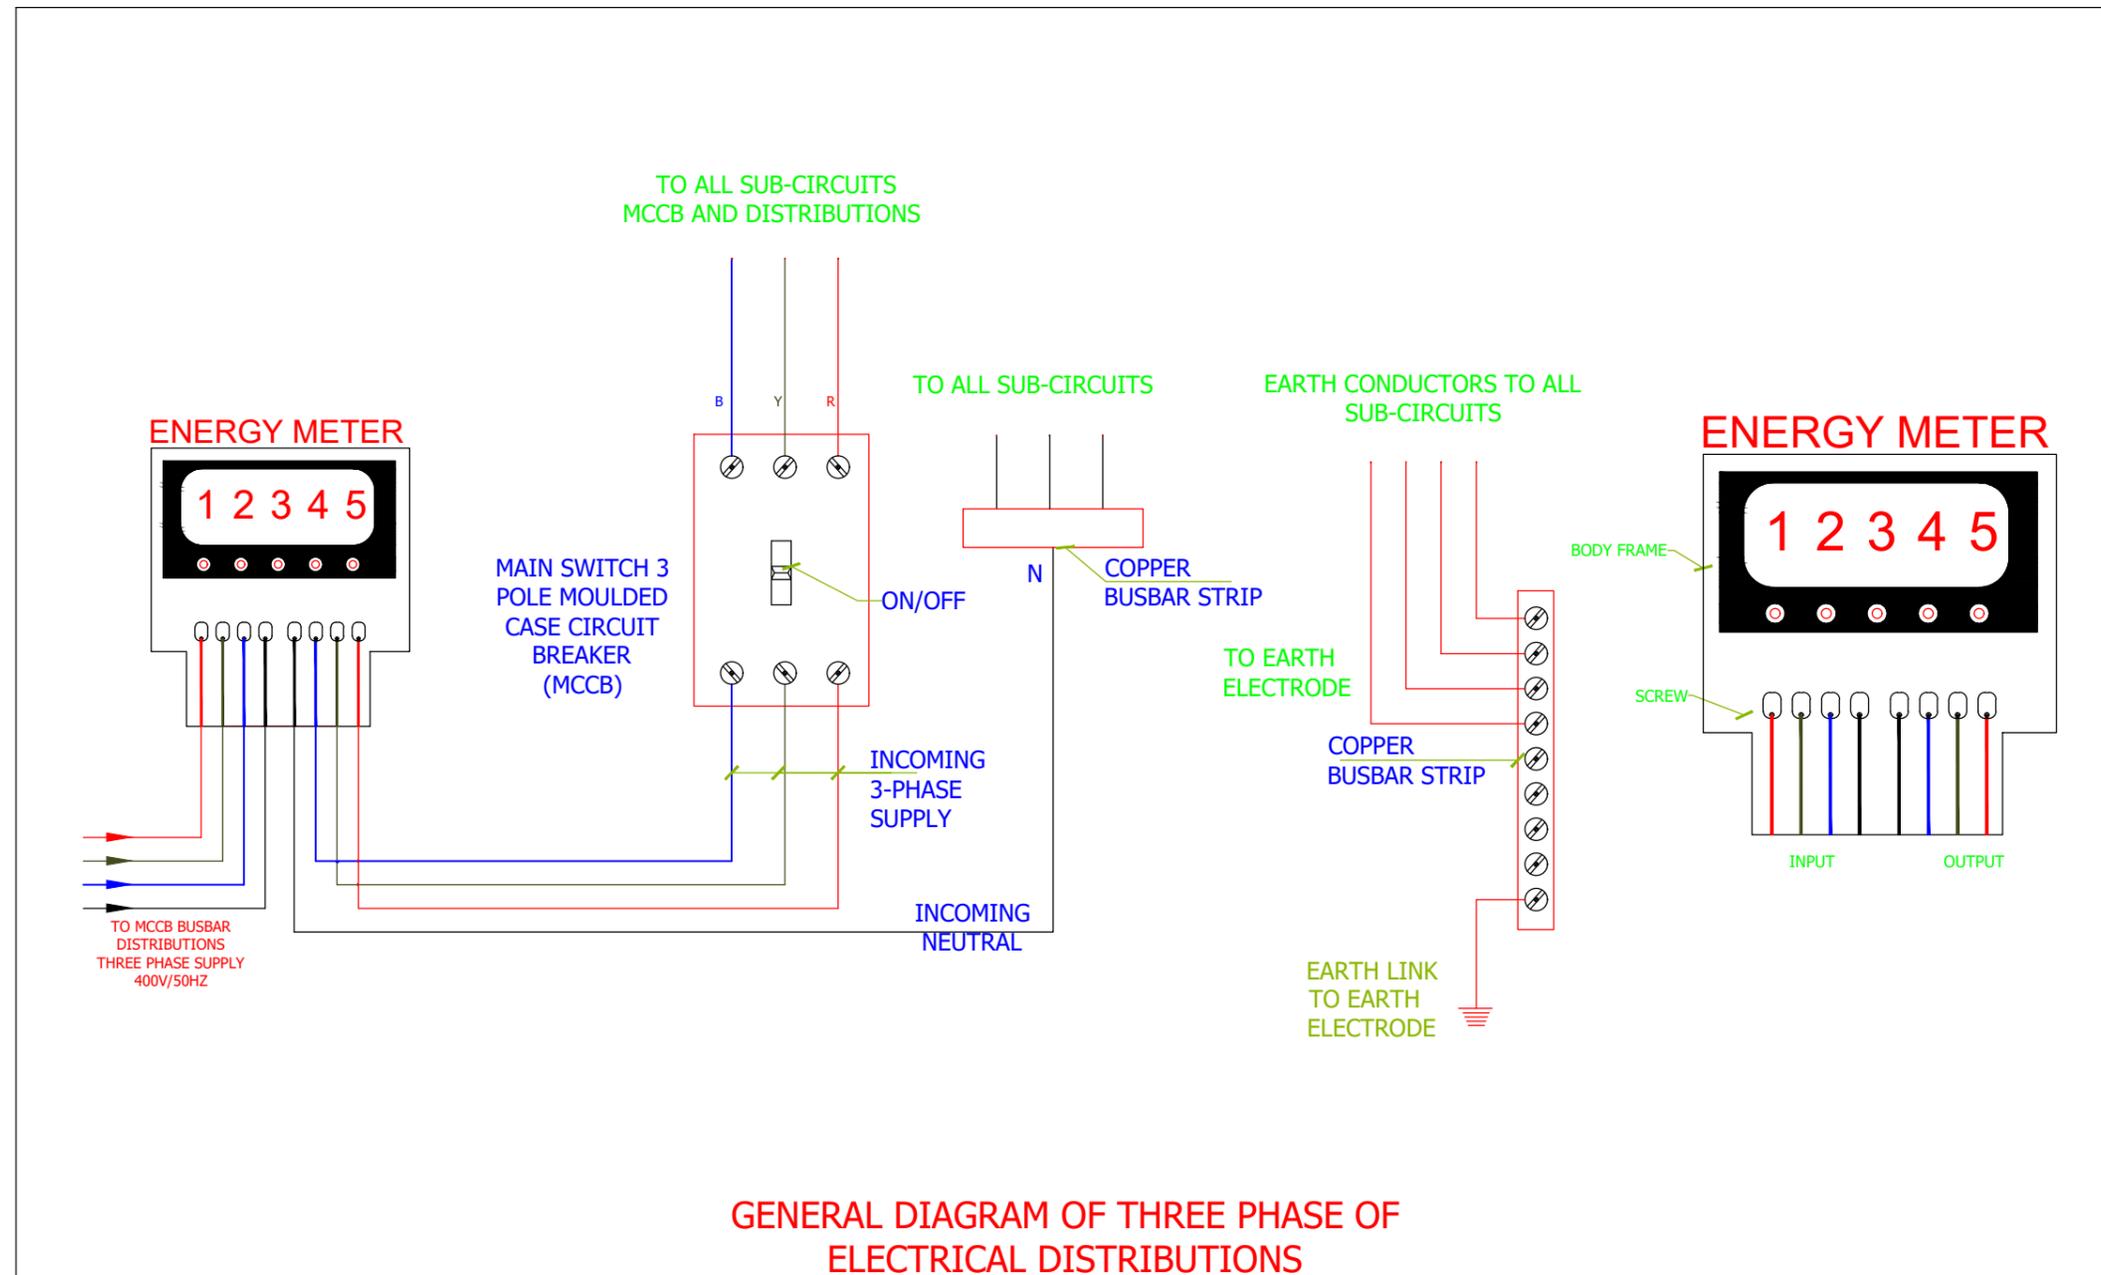

**GENERAL DIAGRAM OF THREE PHASE OF ELECTRICAL DISTRIBUTIONS**

PROJECT:

SCHOOL & SKILL CENTER AT  
BAIKER BALOCHISTAN.

CLIENT:

TAALEEM FOUNDATION

TITLE:

GENERAL DIAGRAM OF THREE PHASE OF  
ELECTRICAL DISTRIBUTIONS

DRAWN BY:

FARMAN ULLAH

CHECKED BY:

Ar. FARUKH RAZZAQ

SCALE:

N. T. S.

DRAWING NO.

E-13


DATE:

NOV- 2025

PLUMBINGDRAWINGS  
FOR  
SCHOOL & SKILL CENTER  
AT BAIKER BALOCHISTAN

CLIENT :  
TAALEEM FOUNDATION.

DATE : 02-NOV-2025

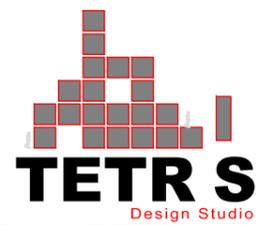

Phone: 03379225835  
Email: tetrisdesignstudio11@gmail.com

LEGENDS		
	SP	SOIL WATER PIPE
	WP	WASTE WATER PIPE
	RP	RAIN WATER PIPE
	CW	COLD WATER SUPPLY PIPE
	FL	FILLING LINE
	HW	HOT WATER SUPPLY
	NG	NATURAL GAS PIPE
		ELECTRIC GEYSER/ ELECTRIC WATER HEATER
		INSTANT GEYSER
		GAS GEYSER
	FD	FLOOR DRAIN
	COP	CLEAN OUT PLUG (ABOVE CEILING)
	COP	CLEAN OUT PLUG (FLOOR LEVEL)
	WMH	WASTE WATER MANHOLE
	SMH	SOIL WATER MANHOLE
	PMH	PRESSURE REDUCE MANHOLE
	CB	CATCH BASIN
	G.T	GULLY TRAP
	OHWT	OVER HEAD WATER TANK
	UGWT	UNDER GROUND WATER TANK
	F/A	FROM ABOVE
	F/B	FROM BELOW
	T/A	TO ABOVE
	T/B	TO BELOW
	U/F	UNDER FLOOR

NOTES	
<b>SANITARY DRAINAGE</b>	
1	ALL PIPES SHALL BE SUITABLY SUPPORTED AND PIPES PASSING THROUGH ROOF STRUCTURE SHALL BE SLEEVED AND PROVIDED WITH COLLARS AND FLASHING TO FORM WATER TIGHT JOINT.
2	ALL VENT PIPES SHALL BE TERMINATED WITH GALVANISED WIRE DOME AND CARRIED 150mm ABOVE THE ROOF.
3	INSPECTION, CLEANING & MANNOLEC EYES SHALL BE PROVIDED ON ALL SOIL AND WASTE PIPES AT EVERY CHANGE OF DIRECTION TO PROVIDE ACCESS FOR CLEANING AND INSPECTION.
4	ALL PIPES SHALL BE CHASED IN WALLS OR FLOOR SLAB WHERE POSSIBLE.
5	CONNECTION OF BRANCH SOIL PIPE TO MAIN STACK SHALL BE AS FOLLOWS:- BRANCH CONNECTION FROM W.C. SHALL BE THE LOWEST AND BRANCH CONNECTIONS FROM BASIN AND FLOOR TRAP SHALL BE ABOVE THIS CONNECTION.
6	THE FALL OF BRANCH SOIL AND WASTE PIPE TOWARDS THE STACK SHALL NOT BE LESS THAN 6mm OR MORE THAN 20mm PER METER LENGTH.
7	ALL MANHOLE COVERS SHALL BE OF HEAVY DUTY CAST IRON FOR TRAFFIC AREA
8	ON THE POINT OF BRANCH CONNECTIONS TO MANHOLES OF THE MAIN SEWER, THE SOFFIT OF THE BRANCH PIPE SHALL NOT BE AT A LOWER LEVEL THAN THE SOFFIT OF THE MAIN SEWER PIPE LEAVING THE MANHOLE.
9	CONTRACTOR SHALL COORDINATE ALL WORKS WITH ELECTRICAL, STRUCTURAL & ARCHITECTURAL DRAWINGS.
10	ALL SEWERAGE PIPING FROM FIXTURES TO MANHOLES AND GULLY TRAPS SHALL BE OF uPVC PIPES CONFORMING TO BS 4514 & LOCAL BYE-LAWS..
11	ALL SEWERAGE PIPING BETWEEN MANHOLES SHALL BE uPVC PIPES OF CLASS-D
12	GULLY TRAP SHALL BE PROVIDED WITH A 'P' TRAP AND CAST IRON FRAME AND COVER WEIGHING APPROXIMATELY 11.33 Kg.
13	ALL EXTERNAL SEWERAGE LINES SHALL HAVE AT LEAST 1% SLOPE.
14	ALL FLOOR DRAIN SHALL BE PROVIDED WITH P-TRAP.
15	INVERT LEVELS INDICATED ON DRAWINGS NEEDS TO BE VERIFIED BY THE CONTRACTOR AS PER SITE CONDITIONS PRIOR TO EXECUTION OF WORK.
16	ALL HORIZONTALLY DRAINAGE PIPES SHALL BE PROVIDED MINIMUM 1% SLOPE IN FLOW DIRECTION.
17	ALL SOIL & WASTE PIPE SHALL HAVE AIR VENT AT THE TOP OF THE BUILDING.

NOTES	
<b>WATER SUPPLY</b>	
1	ALL WATER SUPPLY PIPES WITHIN THE BUILDING SHALL RUN AT HIGH LEVEL UNLESS OTHERWISE SPECIFIED.
2	ALL COLD & HOT WATER SUPPLY PIPES WITHIN THE BUILDING SHALL BE PPR-C (DIN 8077 & 8078 & B.S.S 4991) & AS PER LOCAL BYE-LAWS.
3	PROVIDE ISOLATION (GATE) VALVE ON ALL COLD & HOT WATER SUPPLY LINES AT THE INLET TO EACH TOILET, VALVES SHALL BE INSTALLED IN ACCESSIBLE LOCATIONS.
4	ALL WATER PIPING TO BE TERMINATED WITH SHUT OFF VALVES BEFORE CONNECTION TO FIXTURES I.E WC' S & WASH BASINS.
5	ALL WORK SHALL COMPLY WITH APPLICABLE LOCAL AUTHORITIES BYE-LAWS. AND HEALTH DEPARTMENTS CODES.
<b>STORM WATER DRAINAGE</b>	
1	ALL STORM WATER DRAINAGE PIPES SHALL BE uPVC PIPES OF CLASS -B OR GUTTER CANNEL AS SHOW
2	ALL UNDERGROUND PIPING BETWEEN SHALL BE uPVC PIPES OF CLASS-D

CONSULTANTS :



Phone: 03379225835  
Email:tetrisdesignstudio11@gmail.com

PROJECT:  
SCHOOL & SKILL CENTER  
AT  
BAIKER BALOCHISTAN.

CLIENT:  
TAALEEM FOUNDATION

TITLE:  
MASTER PLAN

DRAWN BY:  
FARMAN ULLAH

CHECKED BY:  
Ar. FARUKH RAZZAQ

SCALE:  
N. T. S.


DRAWING NO. P-01

DATE: NOV- 2025

CONSULTANTS :



Phone: 03379225835  
Email: tetrisdesignstudio11@gmail.com

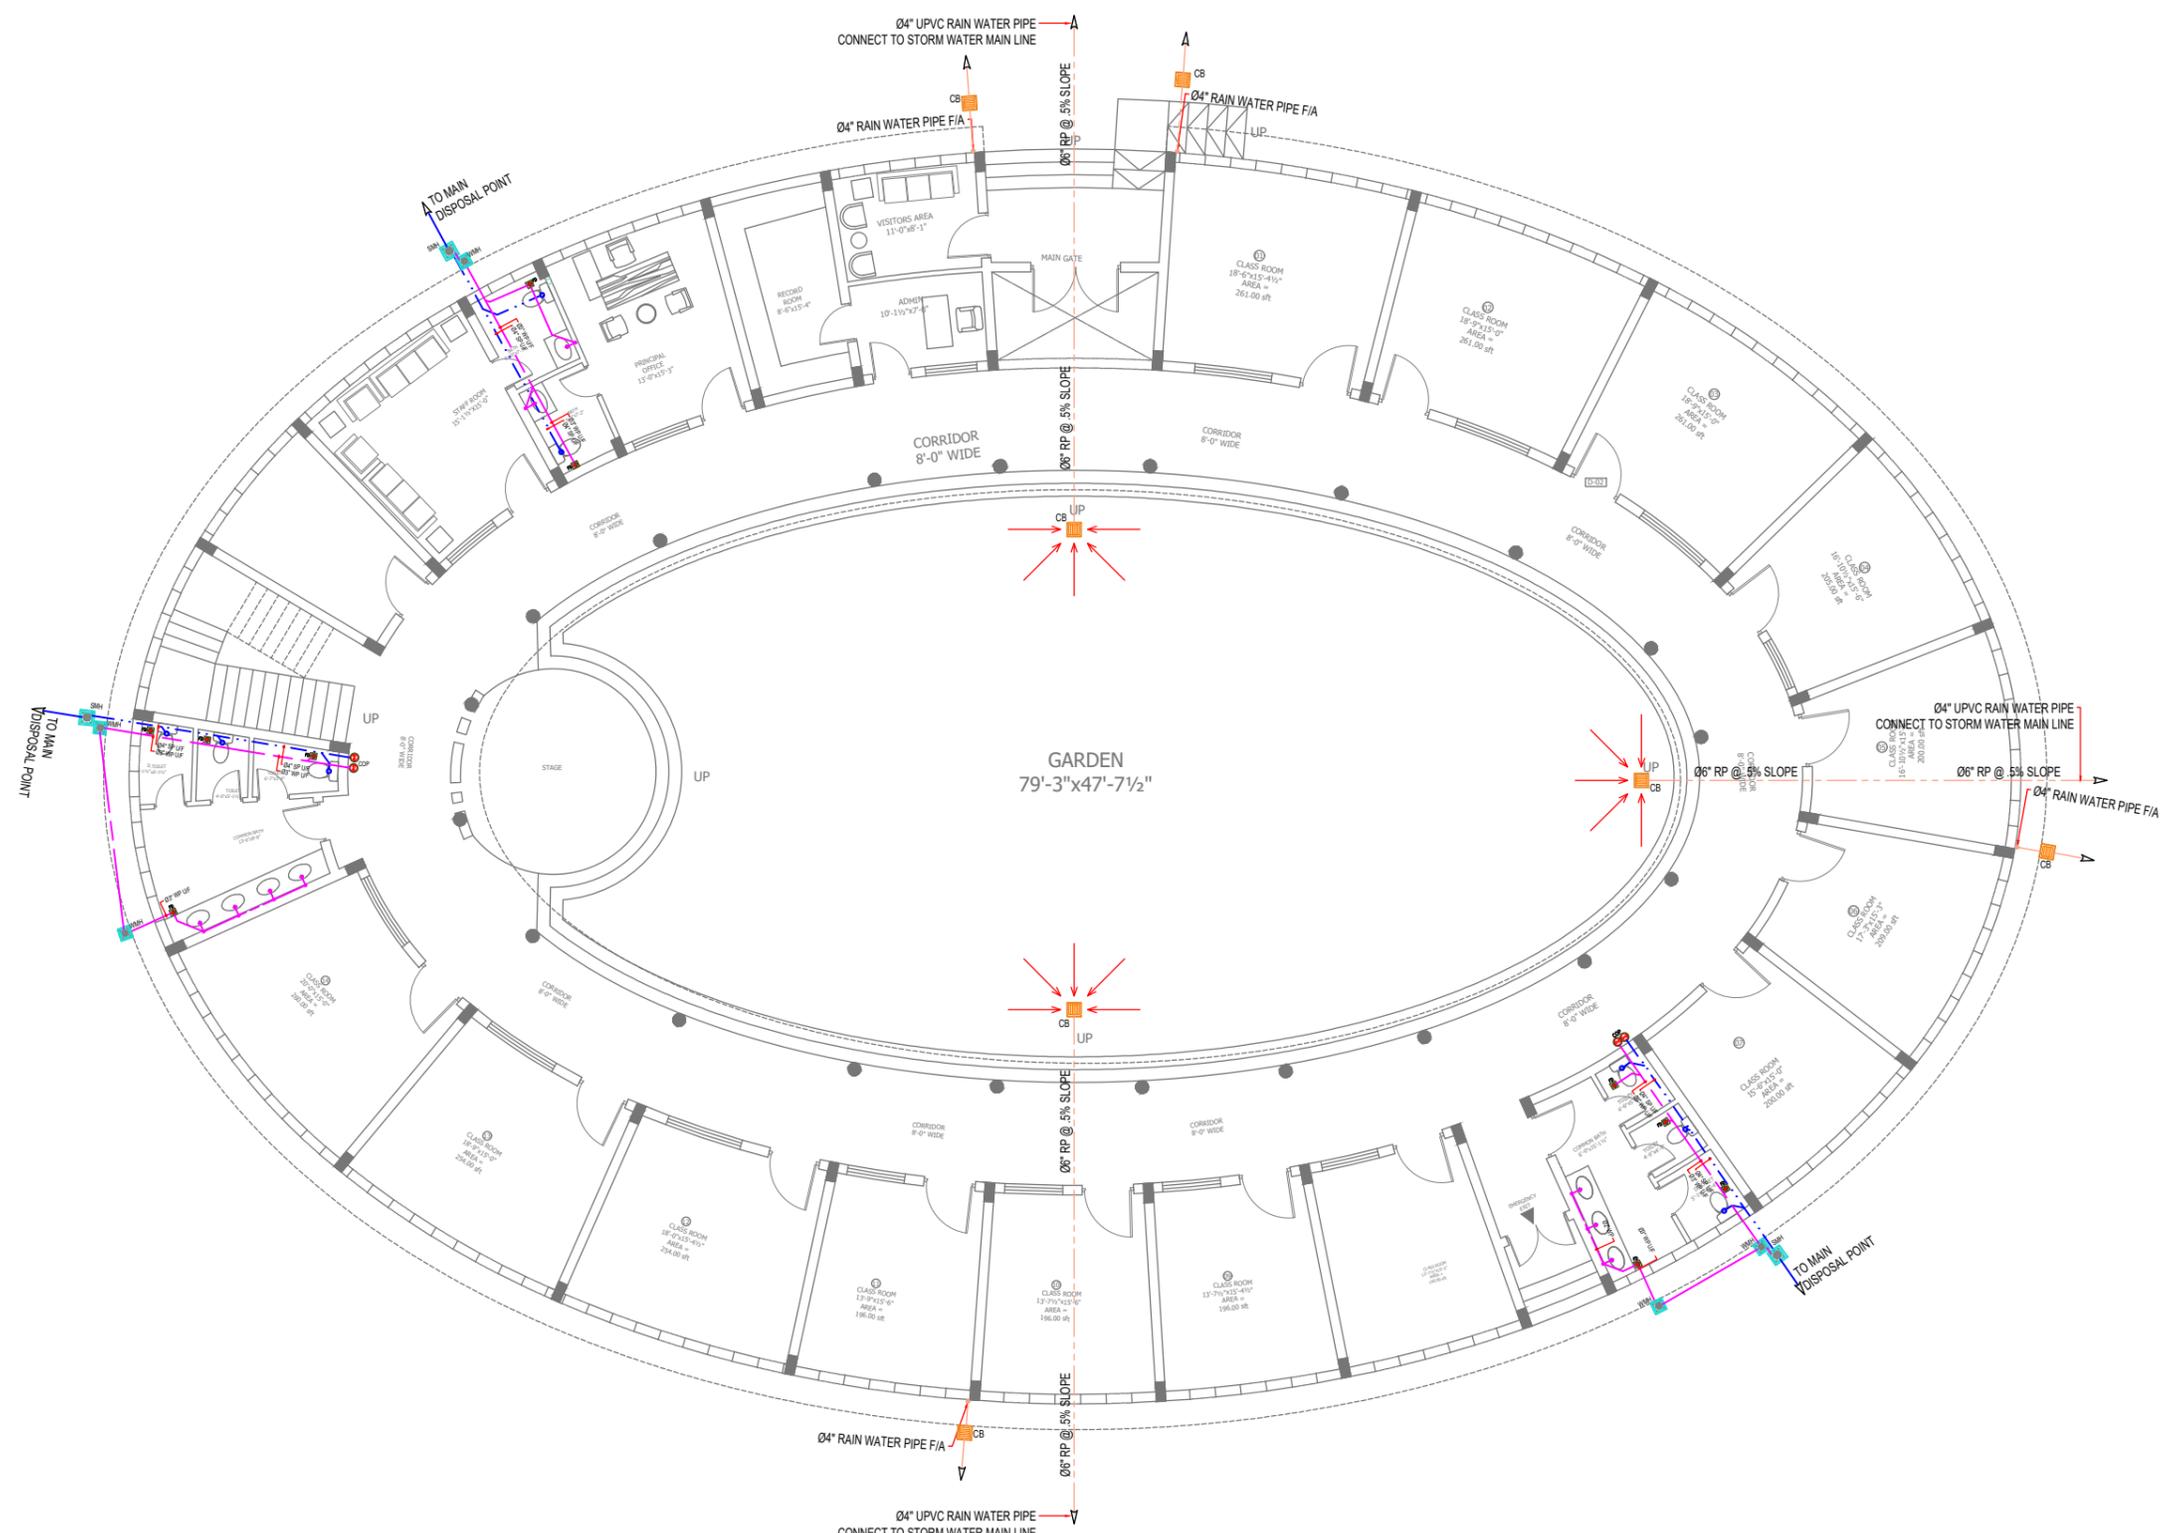

### GROUND FLOOR PLAN

PROJECT:

SCHOOL & SKILL CENTER  
AT  
BAIKER BALOCHISTAN.

CLIENT:

TAALEEM FOUNDATION

TITLE:

SEWERAGE & DRAINAGE  
LAYOUT PLAN

DRAWN BY:

FARMAN ULLAH

CHECKED BY:

Ar. FARUKH RAZZAQ

SCALE:

N. T. S.

DRAWING NO.

P-02

DATE:

NOV- 2025

CONSULTANTS :



Phone: 03379225835  
Email: tetrisdesignstudio11@gmail.com

PROJECT:

SCHOOL & SKILL CENTER  
AT  
BAIKER BALOCHISTAN.

CLIENT:

TAALEEM FOUNDATION

TITLE:

SEWERAGE & DRAINAGE  
LAYOUT PLAN

DRAWN BY:

FARMAN ULLAH

CHECKED BY:

Ar. FARUKH RAZZAQ

SCALE:


N. T. S.

DRAWING NO.

P-03

DATE:

NOV- 2025

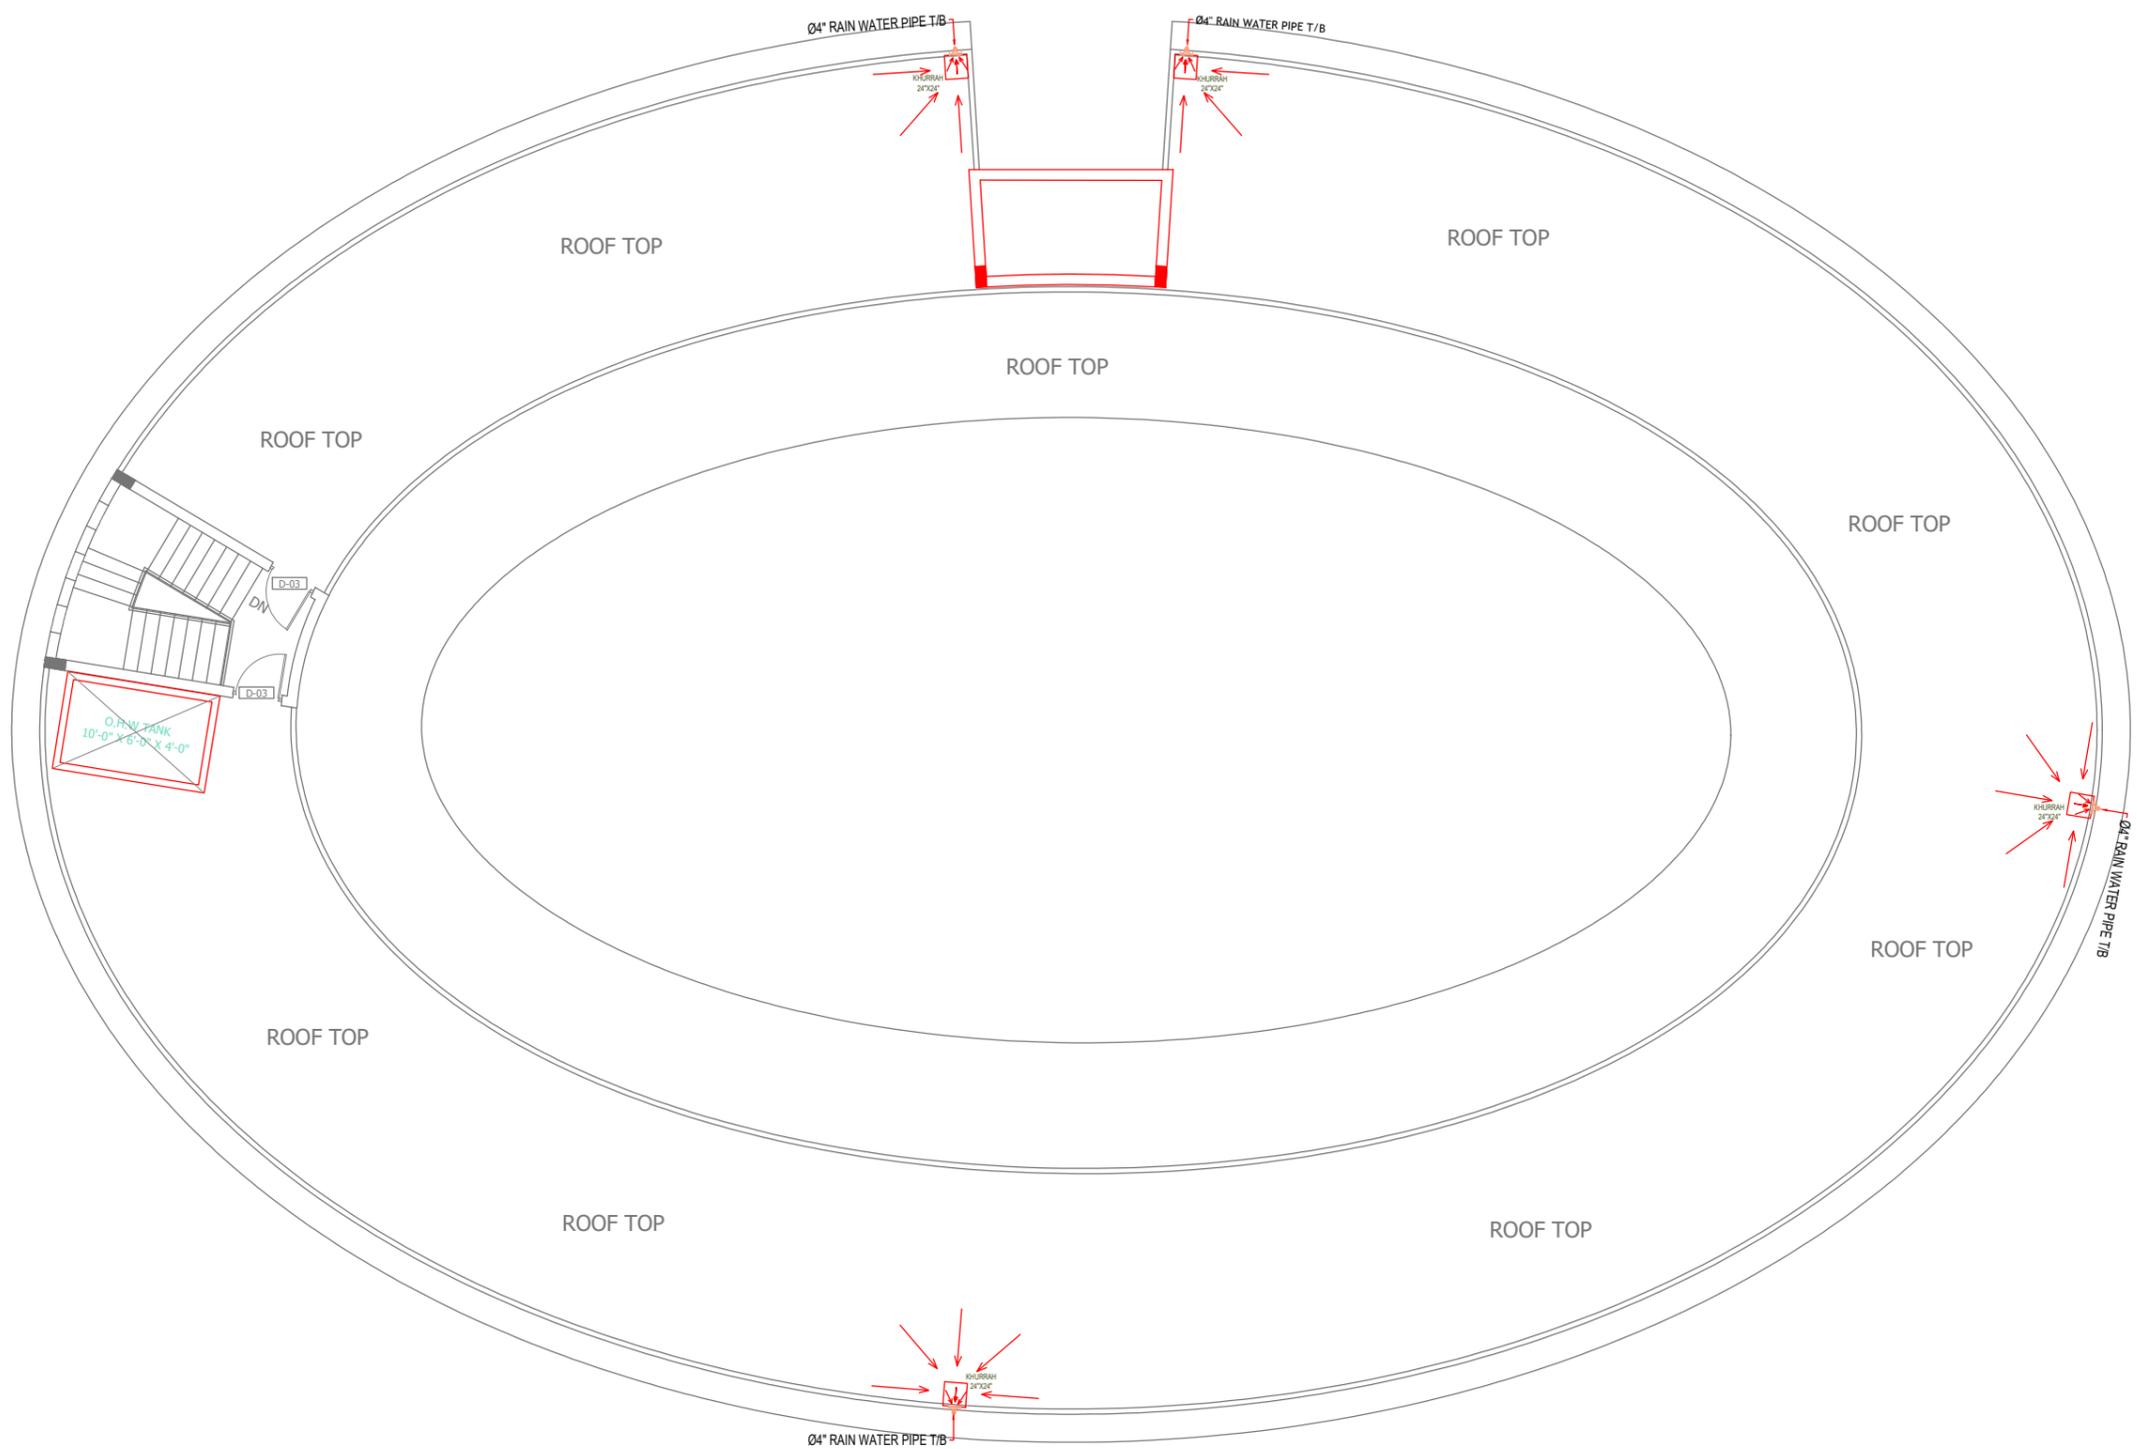


### MUMTY FLOOR PLAN

CONSULTANTS :



Phone: 03379225835  
Email: tetrisdesignstudio11@gmail.com

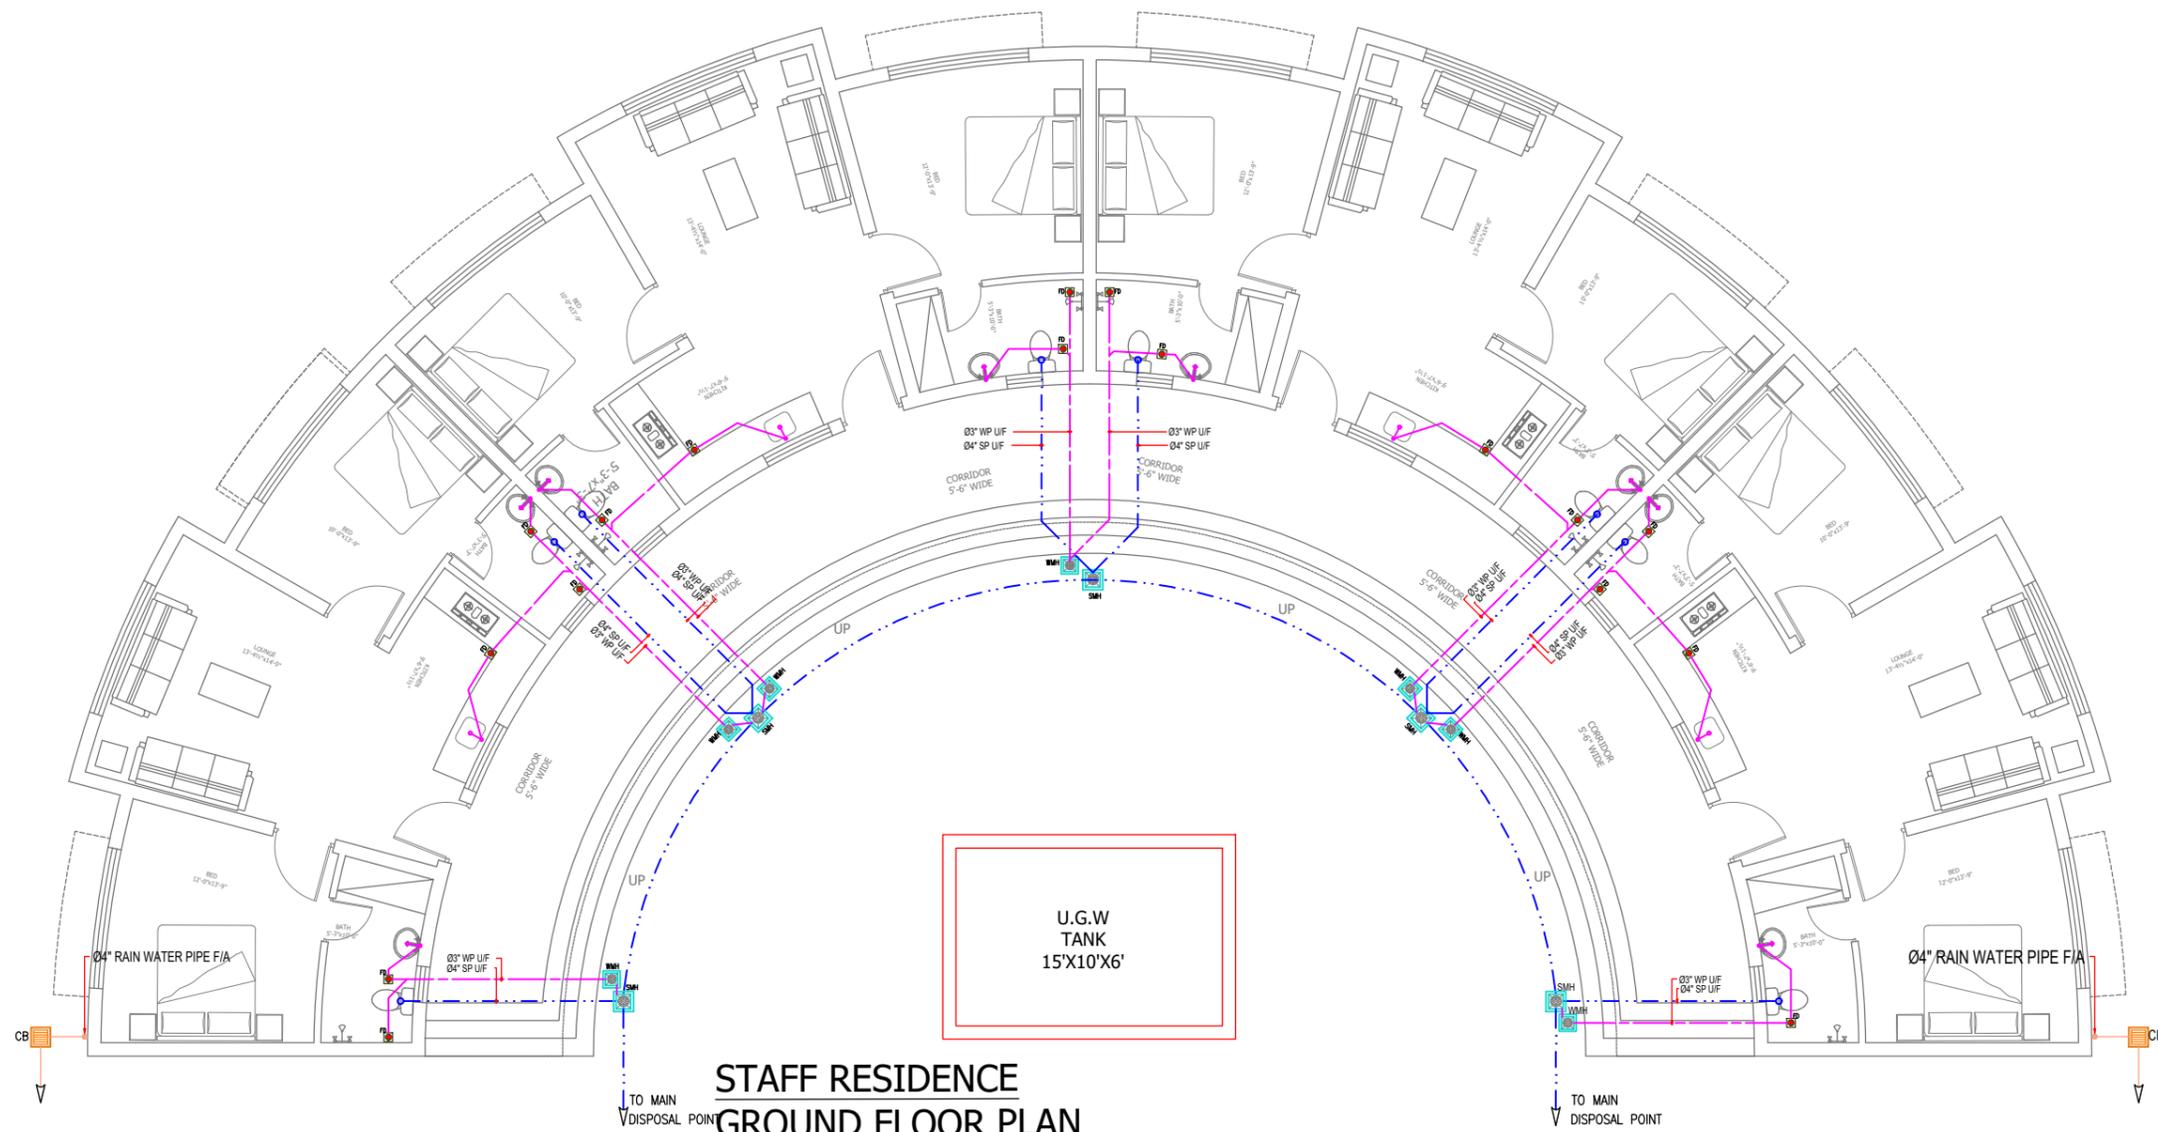

**STAFF RESIDENCE  
GROUND FLOOR PLAN**

PROJECT:

SCHOOL & SKILL CENTER  
AT  
BAIKER BALOCHISTAN.

CLIENT:

TAALEEM FOUNDATION

TITLE:

SEWERAGE & DRAINAGE  
LAYOUT PLAN

DRAWN BY:

FARMAN ULLAH

CHECKED BY:

Ar. FARUKH RAZZAQ

SCALE:

N. T. S.

DRAWING NO.

P-04


DATE:

NOV- 2025

CONSULTANTS :



Phone: 03379225835  
Email: tetrisdesignstudio11@gmail.com

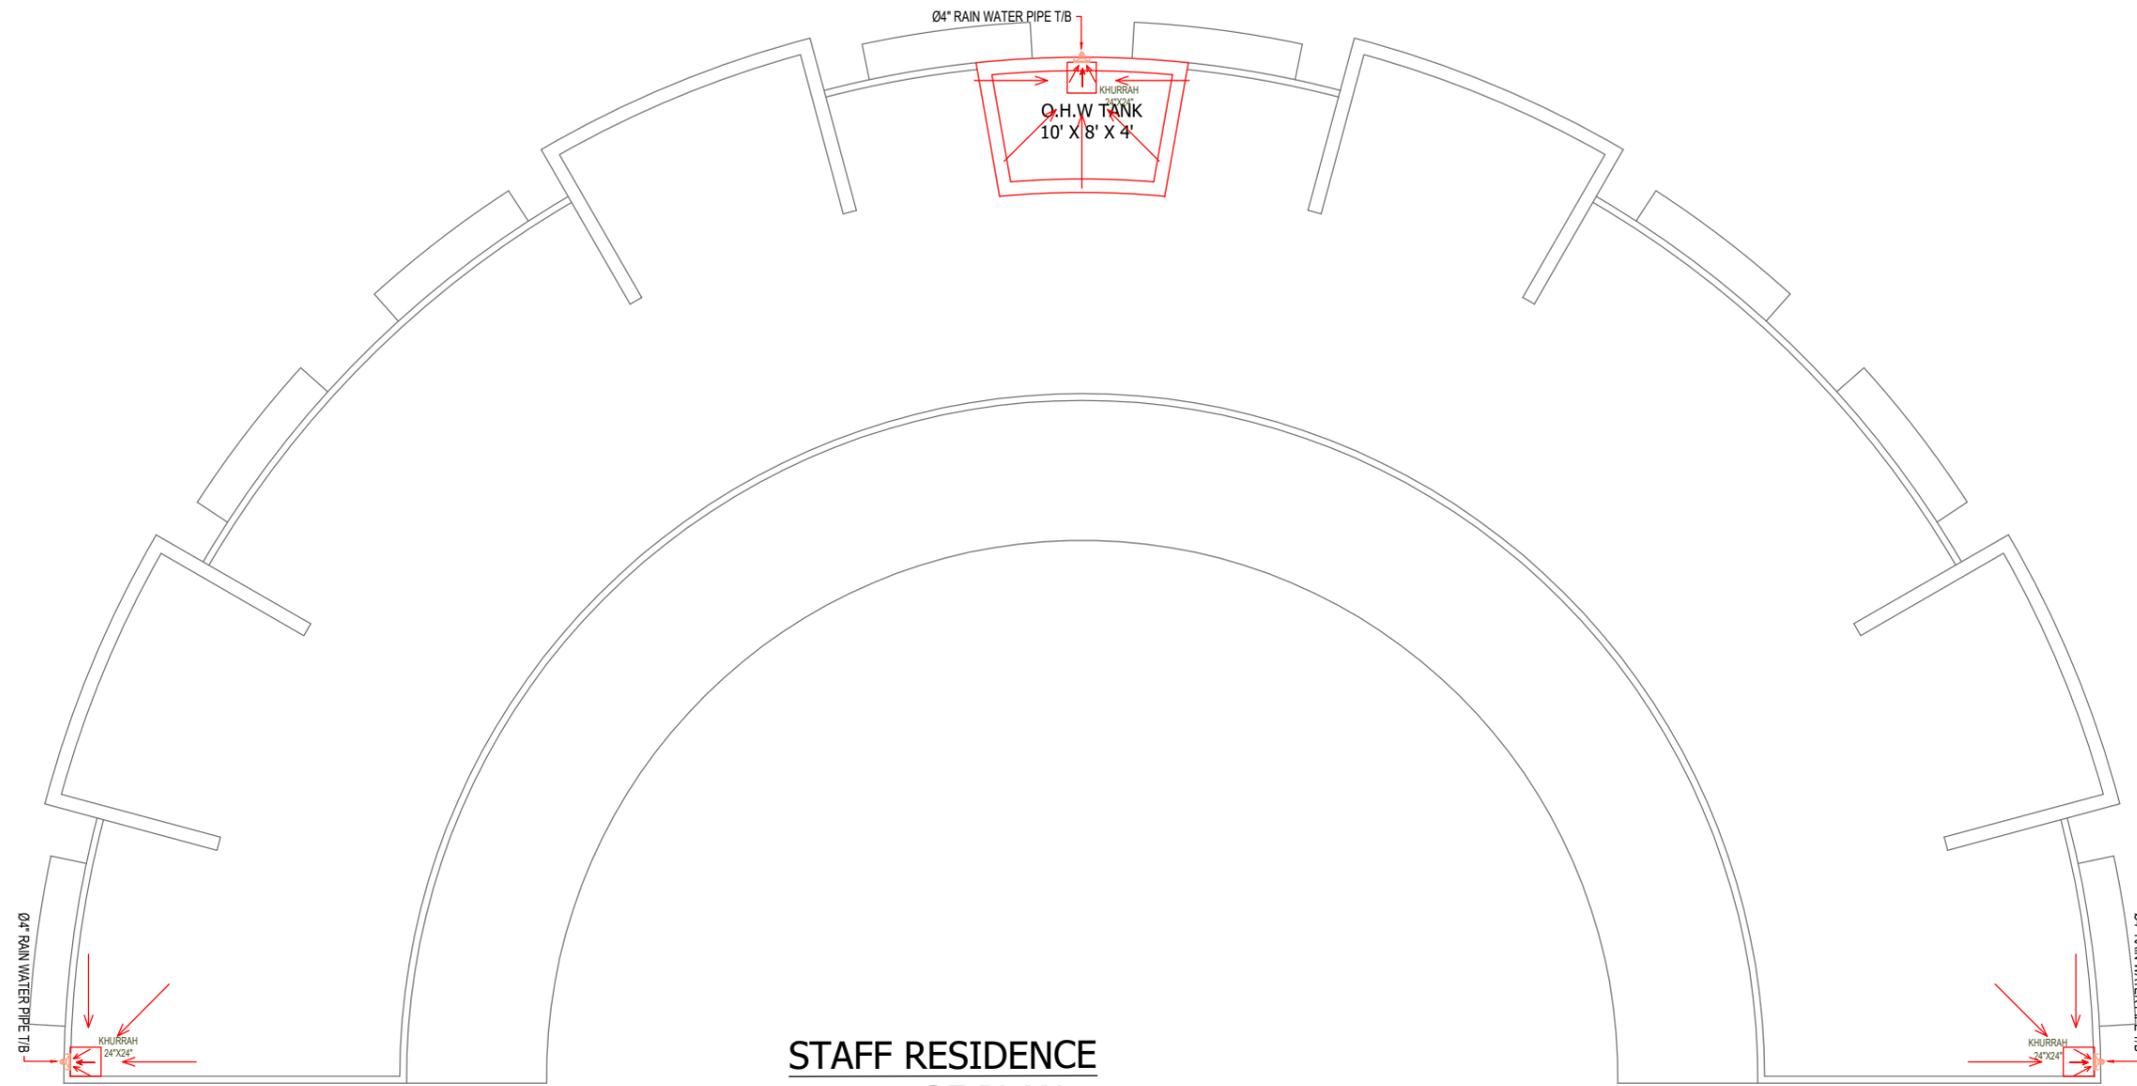

**STAFF RESIDENCE  
TOP ROOF PLAN**

PROJECT:

SCHOOL & SKILL CENTER  
AT  
BAIKER BALOCHISTAN.

CLIENT:

TAALEEM FOUNDATION

TITLE:

SEWERAGE & DRAINAGE  
LAYOUT PLAN

DRAWN BY:

FARMAN ULLAH

CHECKED BY:

Ar. FARUKH RAZZAQ

SCALE:


N. T. S.

DRAWING NO.

P-05

DATE:

NOV- 2025

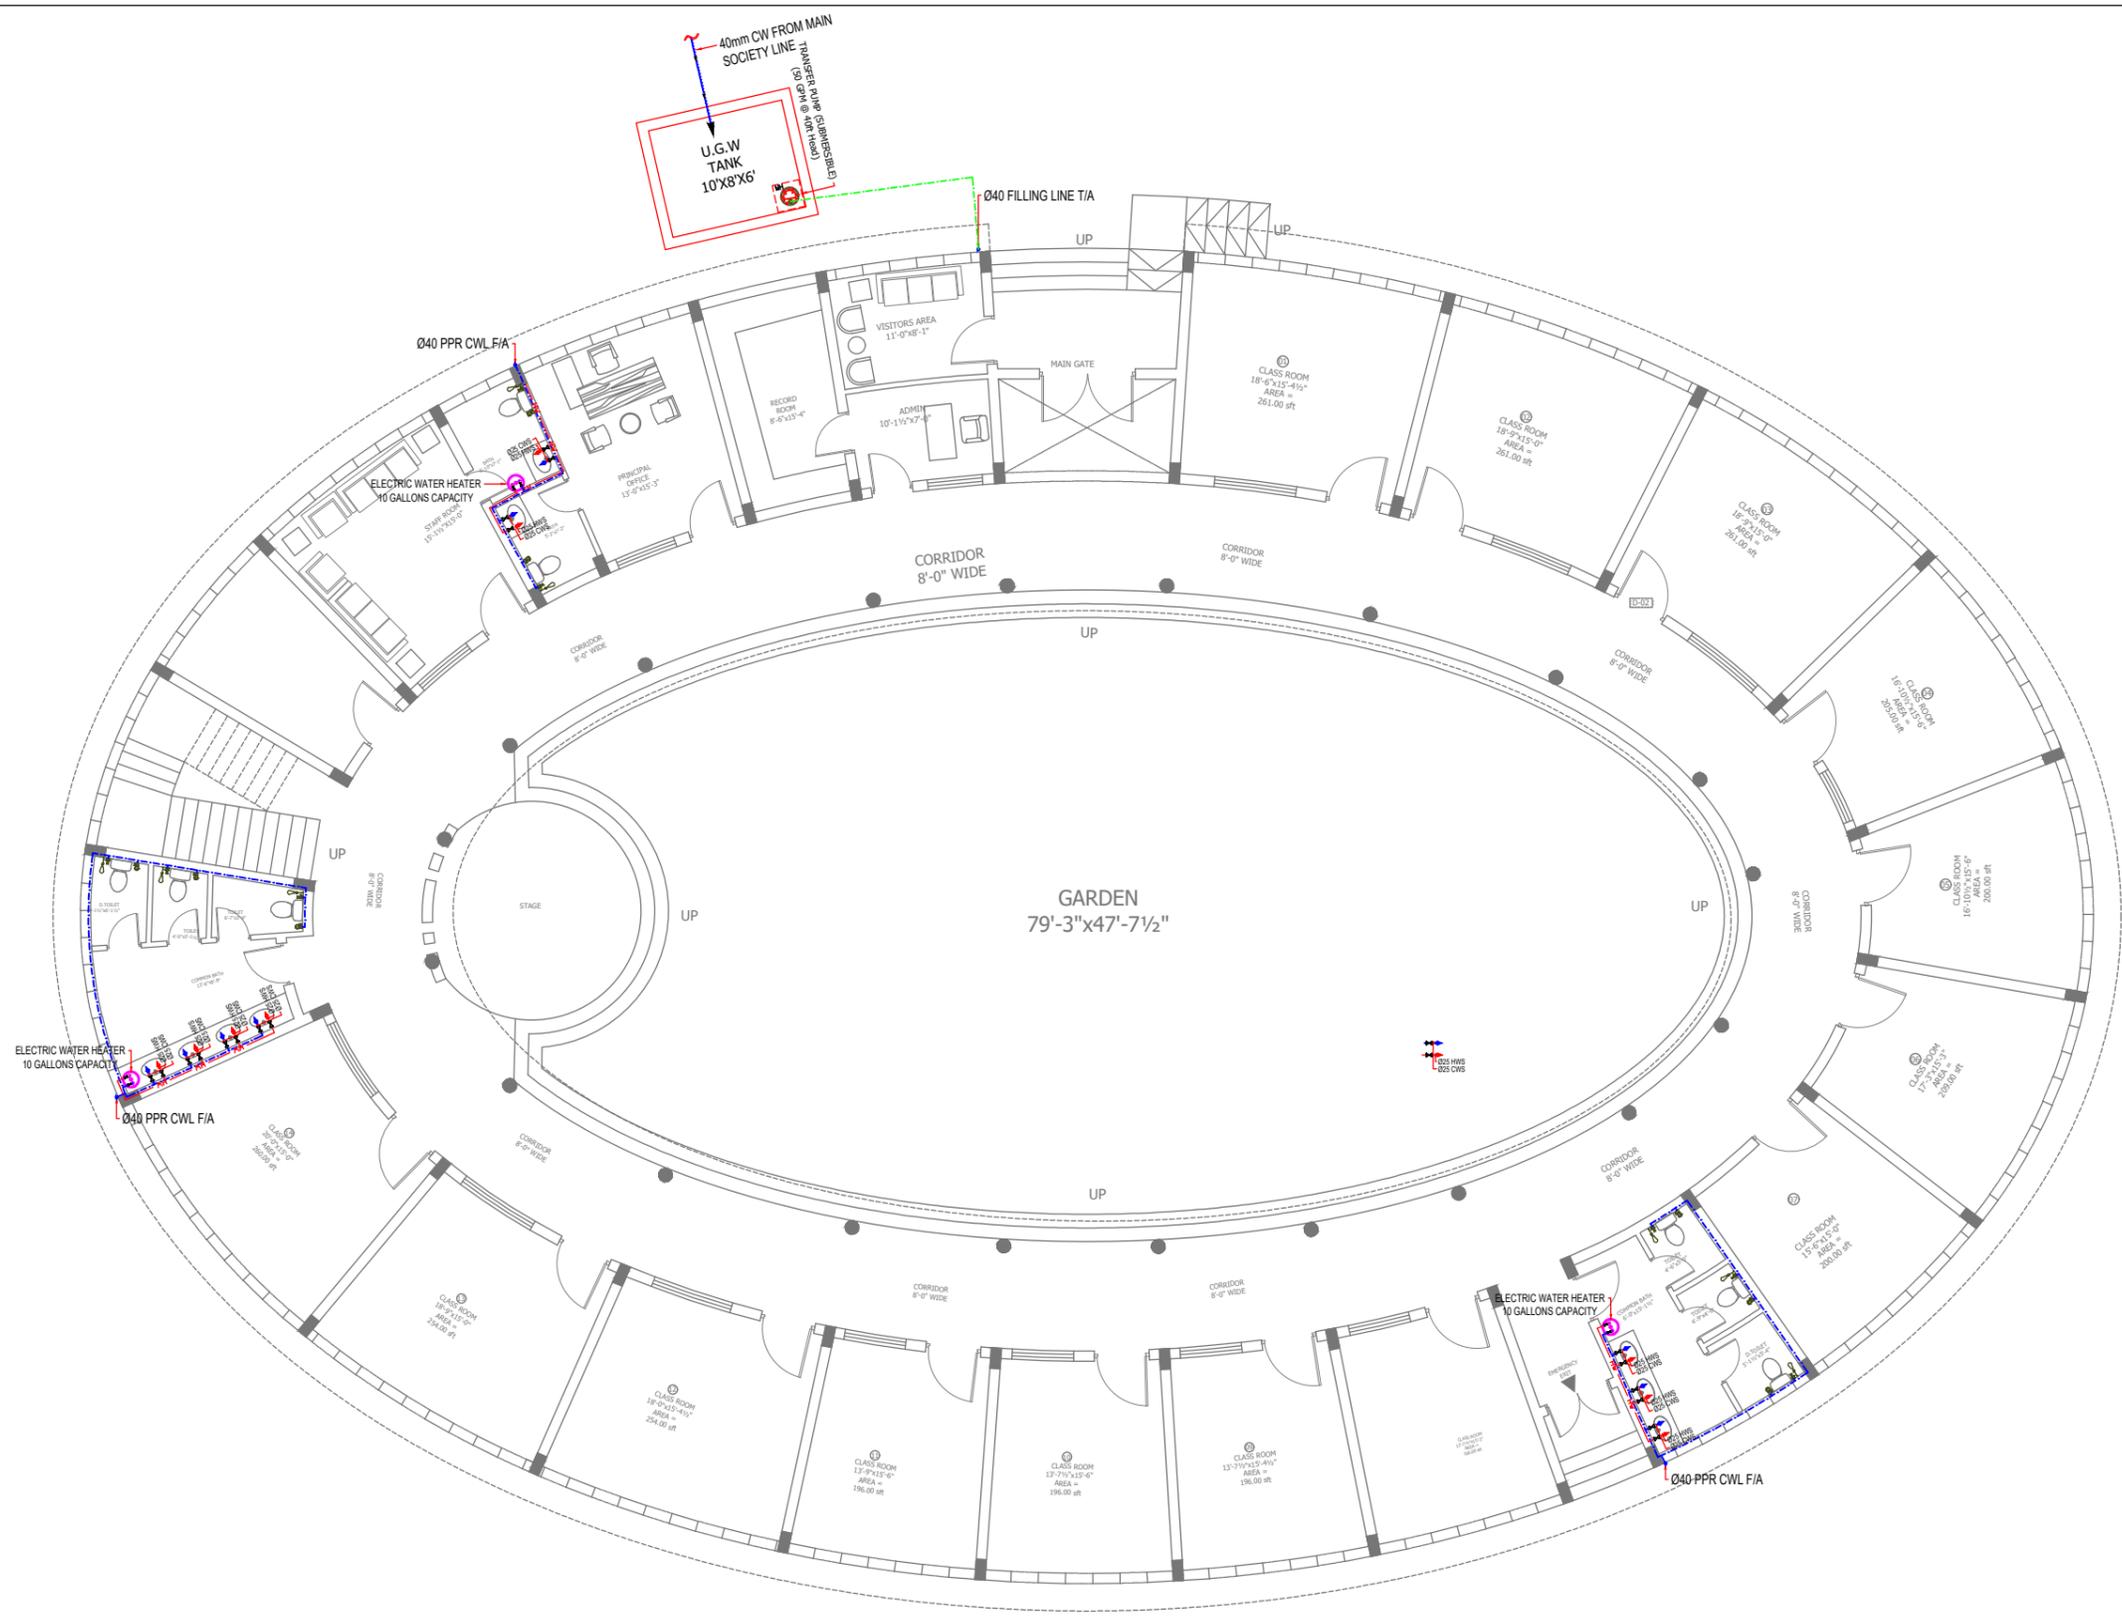

# GROUND FLOOR PLAN

CONSULTANTS :



PROJECT:

SCHOOL & SKILL CENTER  
AT  
BAIKER BALOCHISTAN.

CLIENT:

TAALEEM FOUNDATION

TITLE:

WATER SUPPLY LAYOUT PLAN

DRAWN BY:

FARMAN ULLAH

CHECKED BY:

Ar. FARUKH RAZZAQ

SCALE:

N. T. S.

DRAWING NO. P-06

DATE: NOV- 2025

CONSULTANTS :



Phone: 03379225835  
Email: tetrisdesignstudio11@gmail.com

PROJECT:

SCHOOL & SKILL CENTER  
AT  
BAIKER BALOCHISTAN.

CLIENT:

TAALEEM FOUNDATION

TITLE:

WATER SUPPLY LAYOUT PLAN

DRAWN BY:

FARMAN ULLAH

CHECKED BY:

Ar. FARUKH RAZZAQ

SCALE:


N. T. S.

DRAWING NO.

P-07

DATE:

NOV- 2025

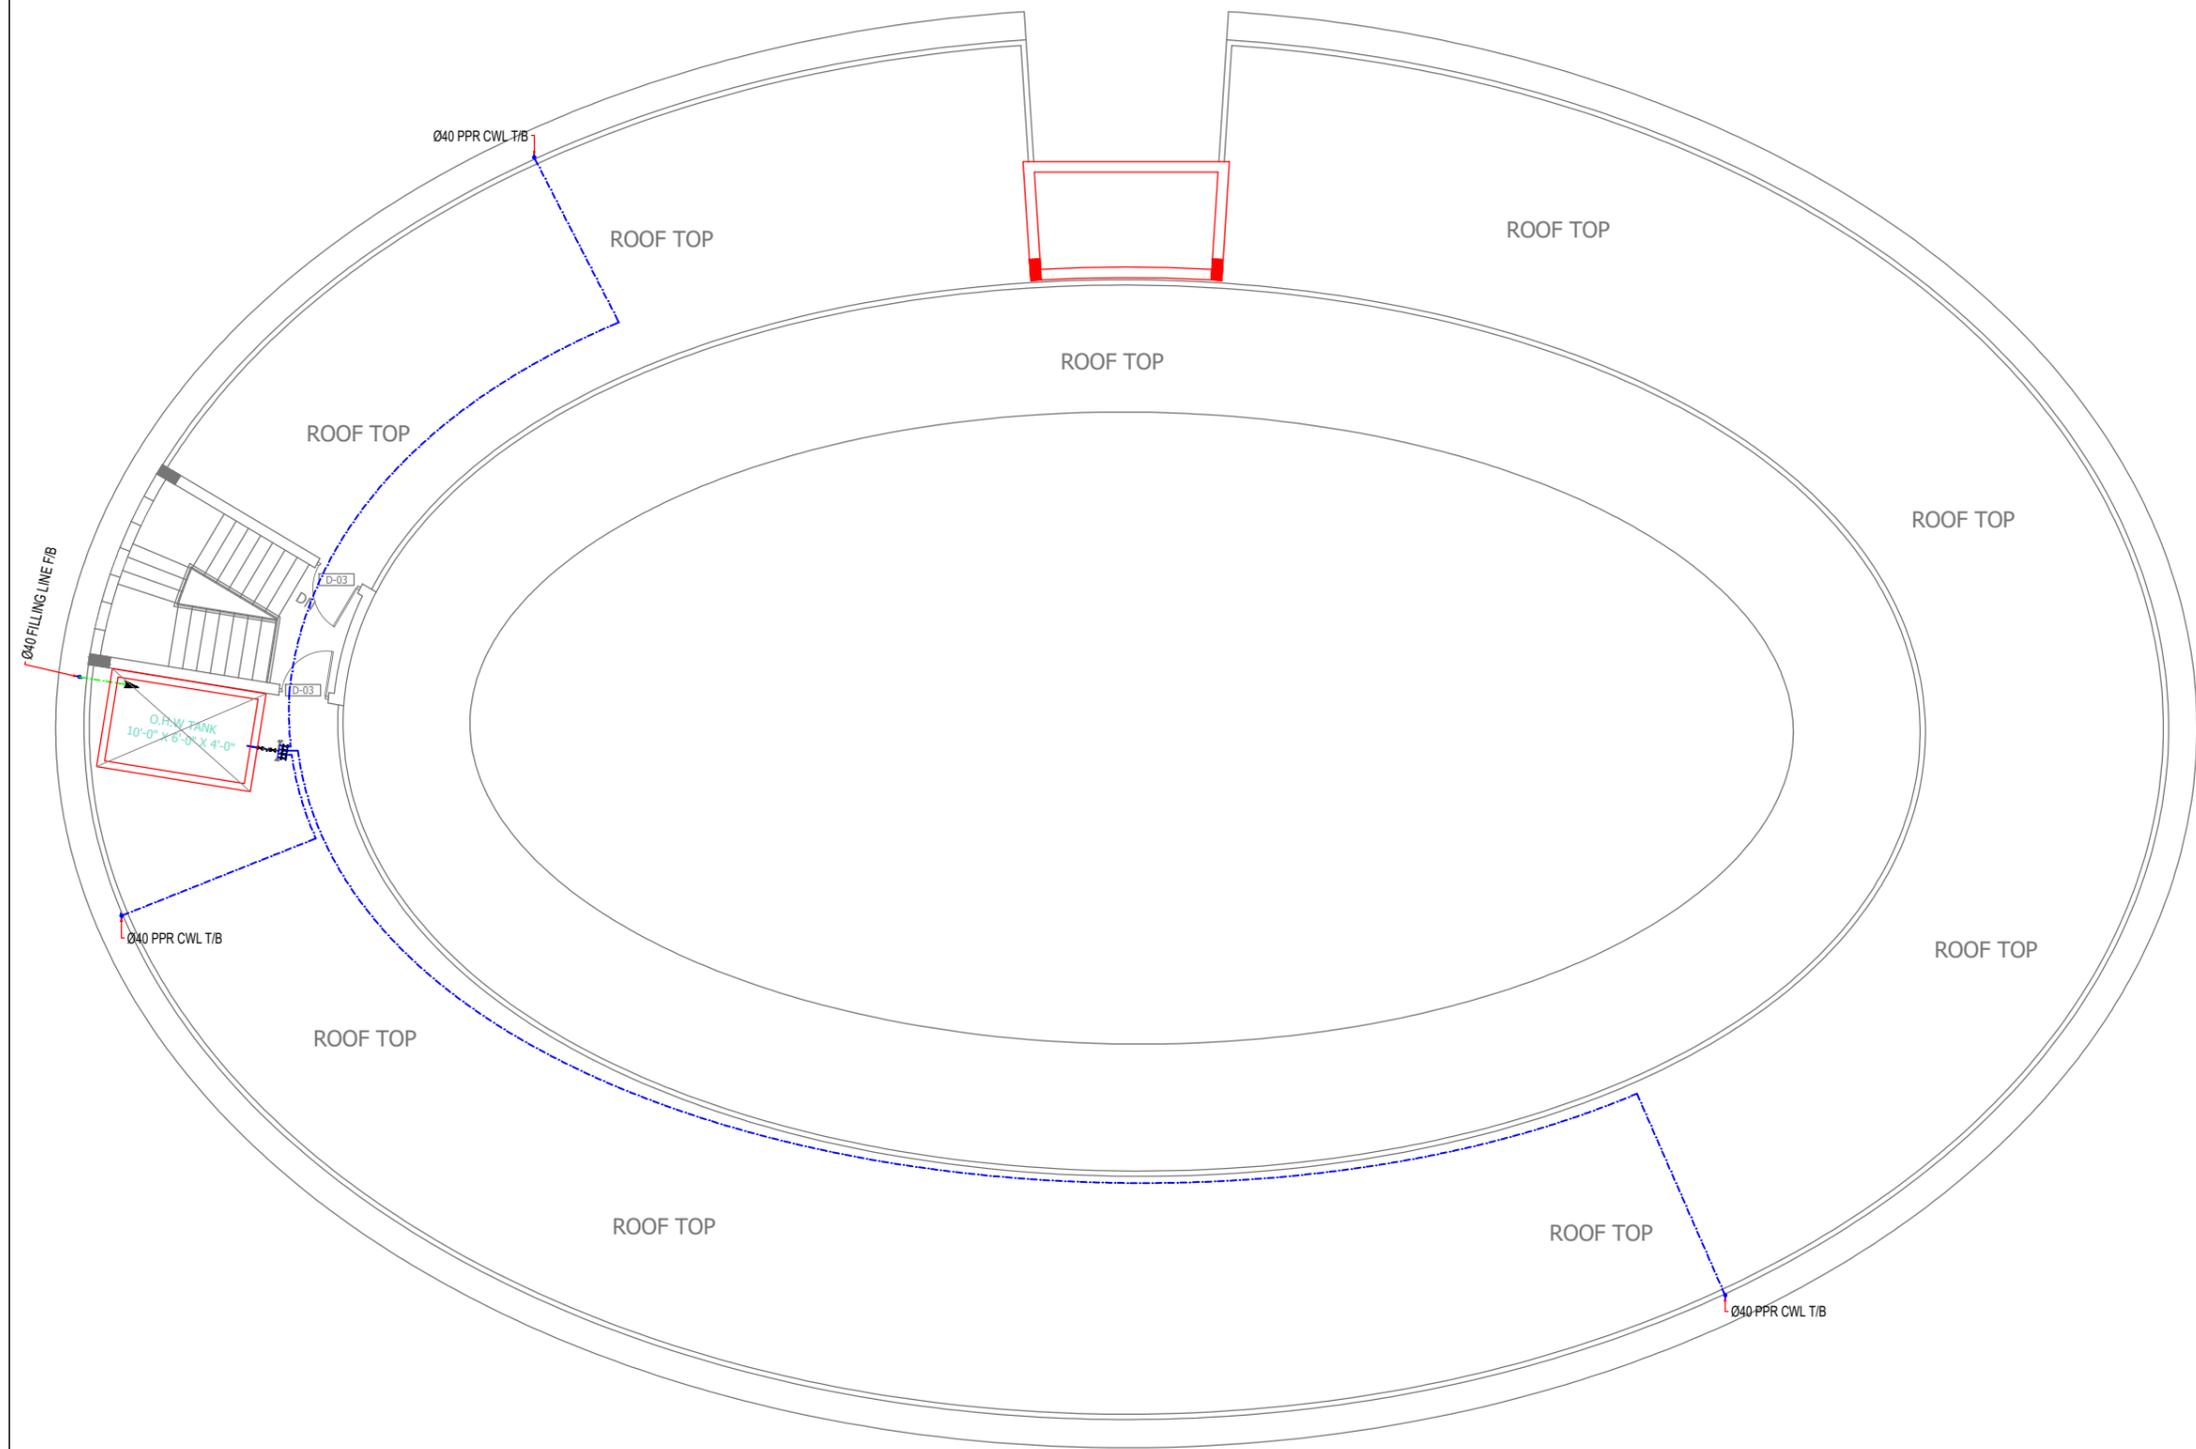


MUMTY FLOOR PLAN


CONSULTANTS :



Phone: 03379225835  
Email: tetrdesignstudio11@gmail.com

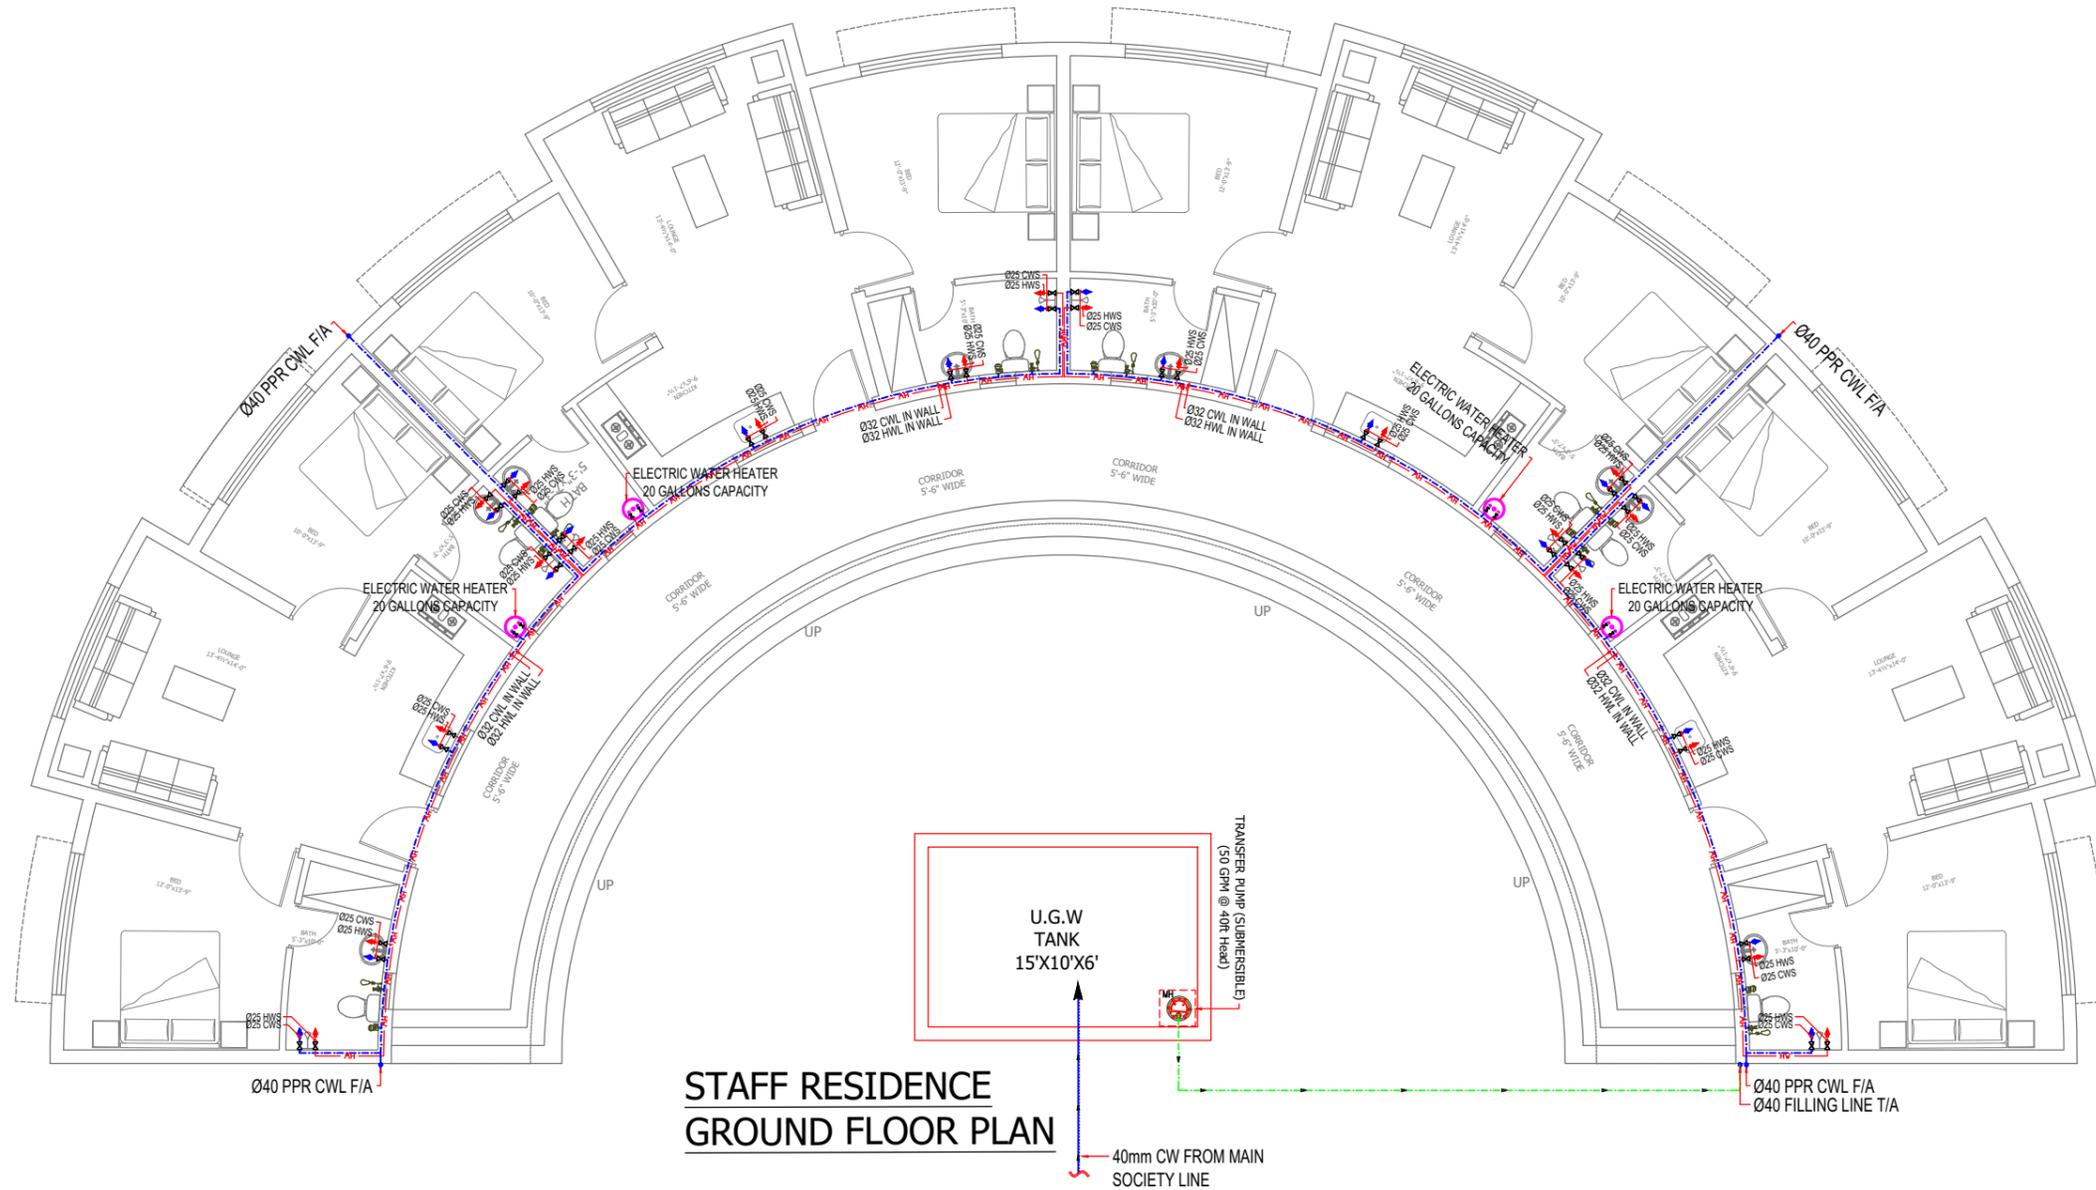

**STAFF RESIDENCE  
GROUND FLOOR PLAN**

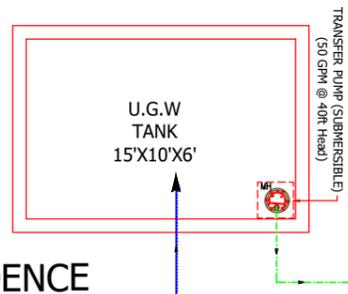

40mm CW FROM MAIN SOCIETY LINE

PROJECT:

SCHOOL & SKILL CENTER  
AT  
BAIKER BALOCHISTAN.

CLIENT:

TAALEEM FOUNDATION

TITLE:

WATER SUPPLY LAYOUT PLAN

DRAWN BY:

FARMAN ULLAH

CHECKED BY:

Ar. FARUKH RAZZAQ

SCALE:

N. T. S.

DRAWING NO.

P-08


DATE:

NOV- 2025

CONSULTANTS :



Phone: 03379225835  
Email:tetrisdesignstudio11@gmail.com

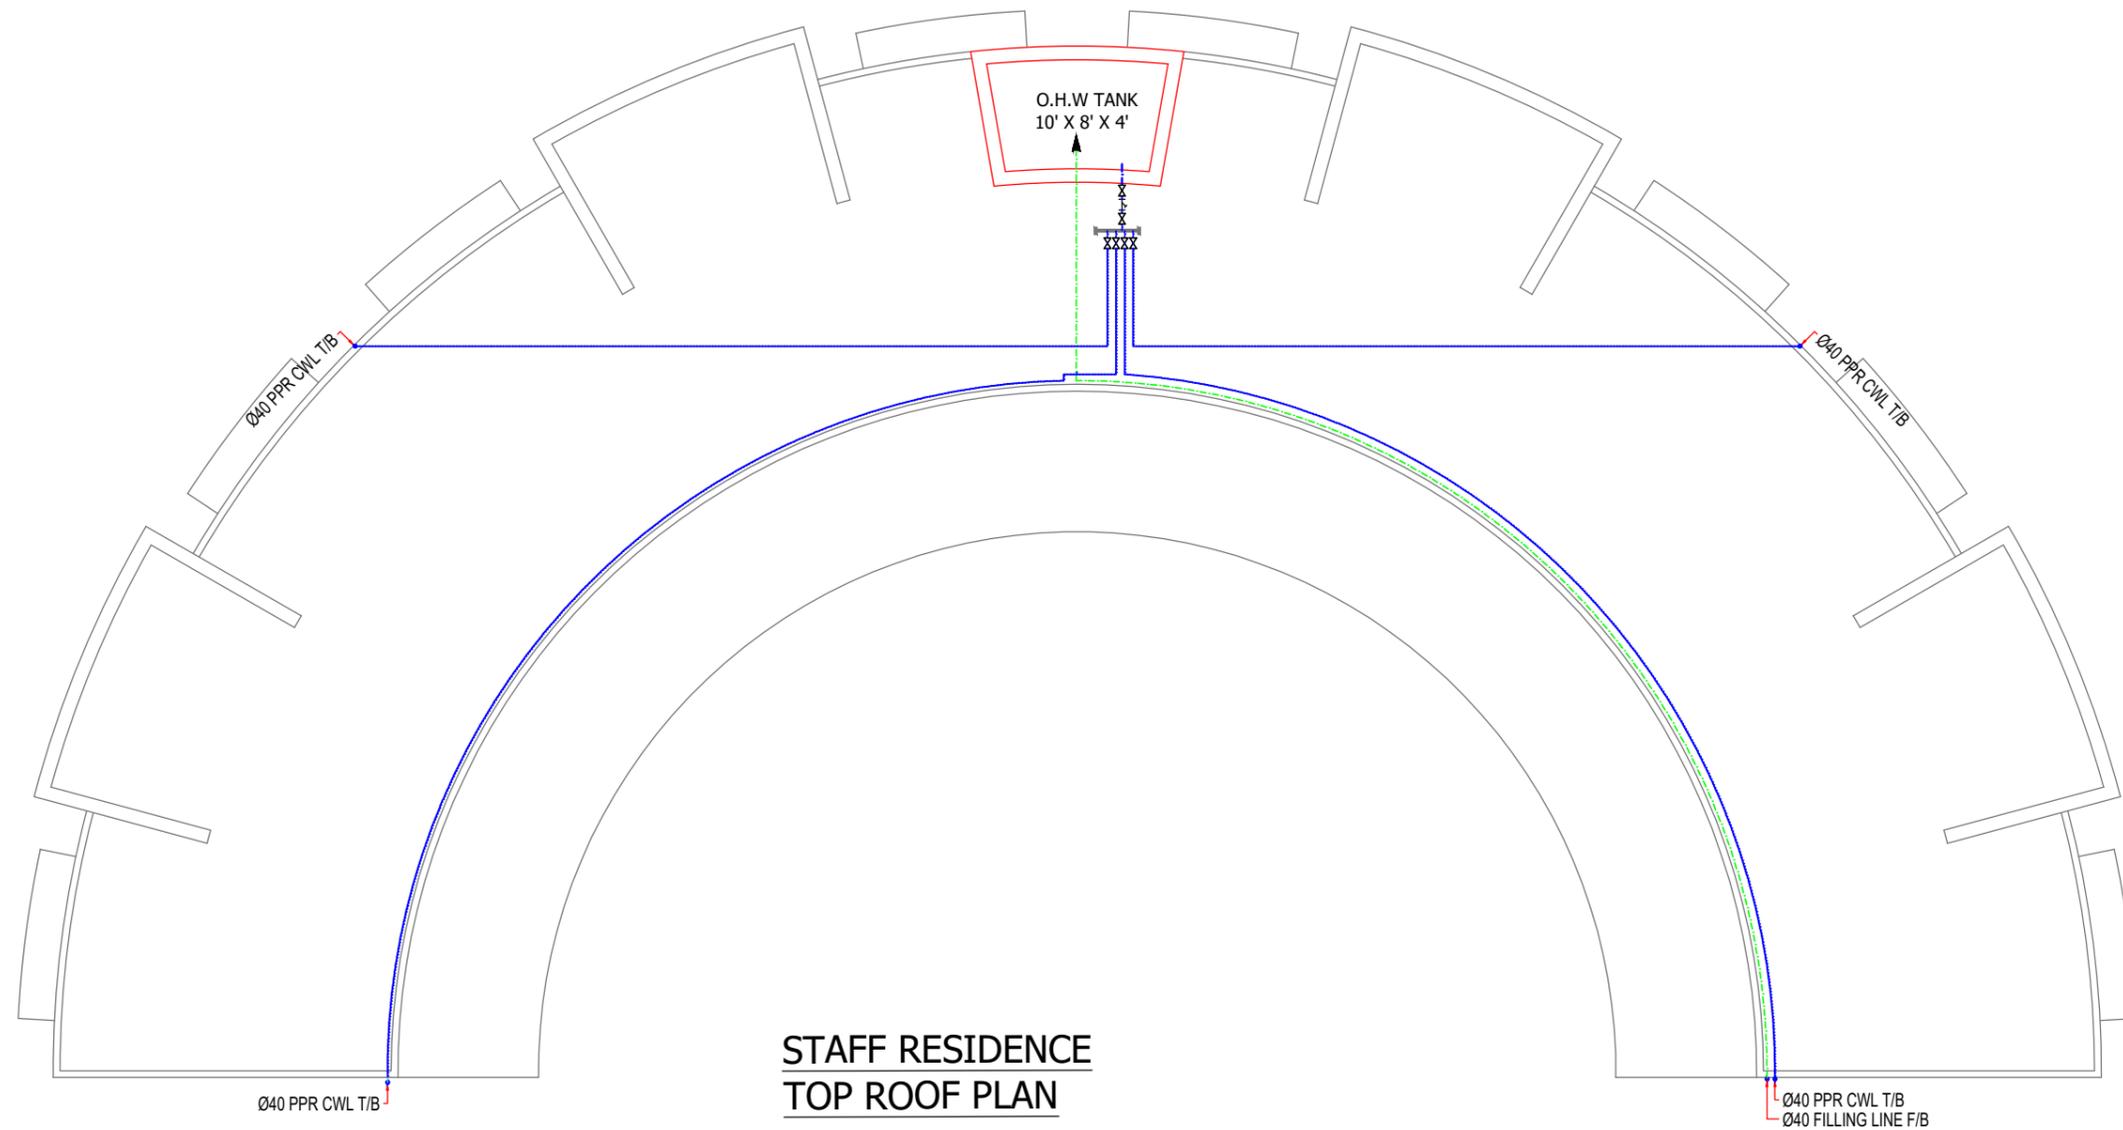

PROJECT:

SCHOOL & SKILL CENTER  
AT  
BAIKER BALOCHISTAN.

CLIENT:

TAALEEM FOUNDATION

TITLE:

WATER SUPPLY LAYOUT PLAN

DRAWN BY:

FARMAN ULLAH

CHECKED BY:

Ar. FARUKH RAZZAQ

SCALE:




N. T. S.

DRAWING NO.

P-09

DATE:

NOV- 2025

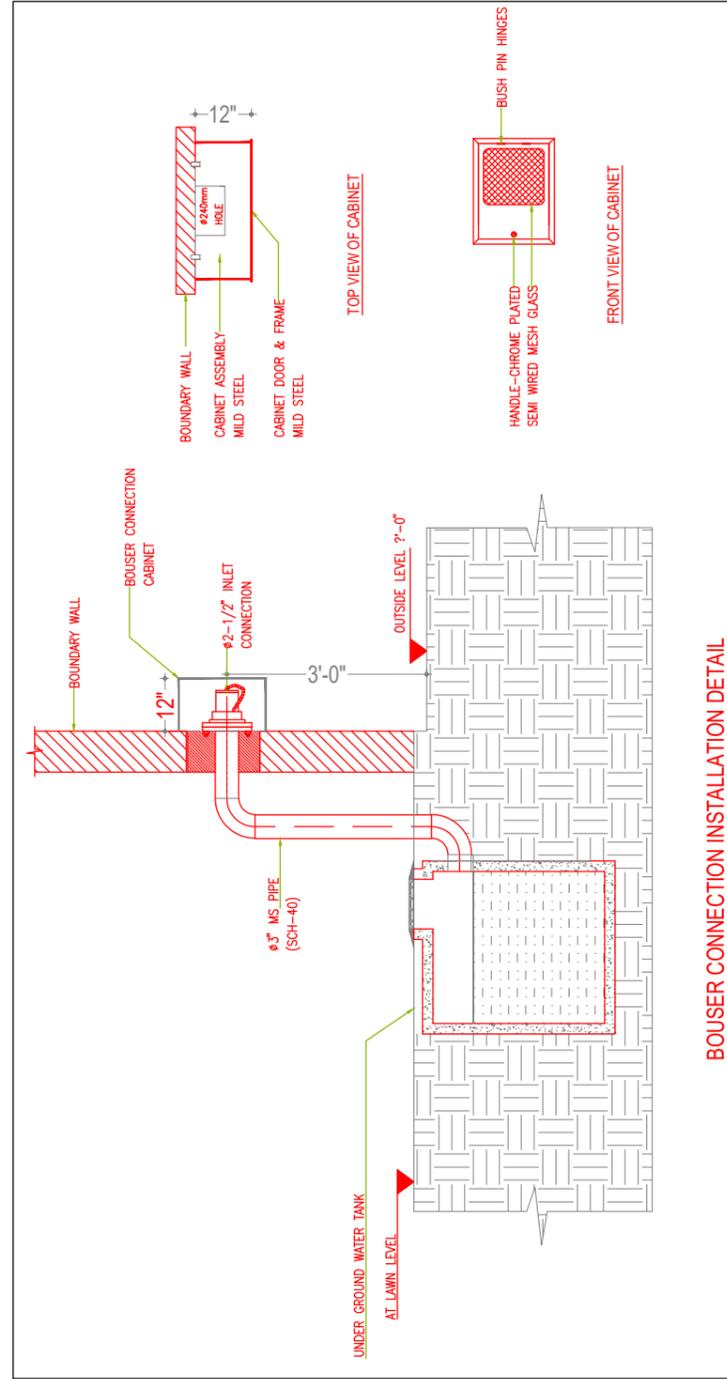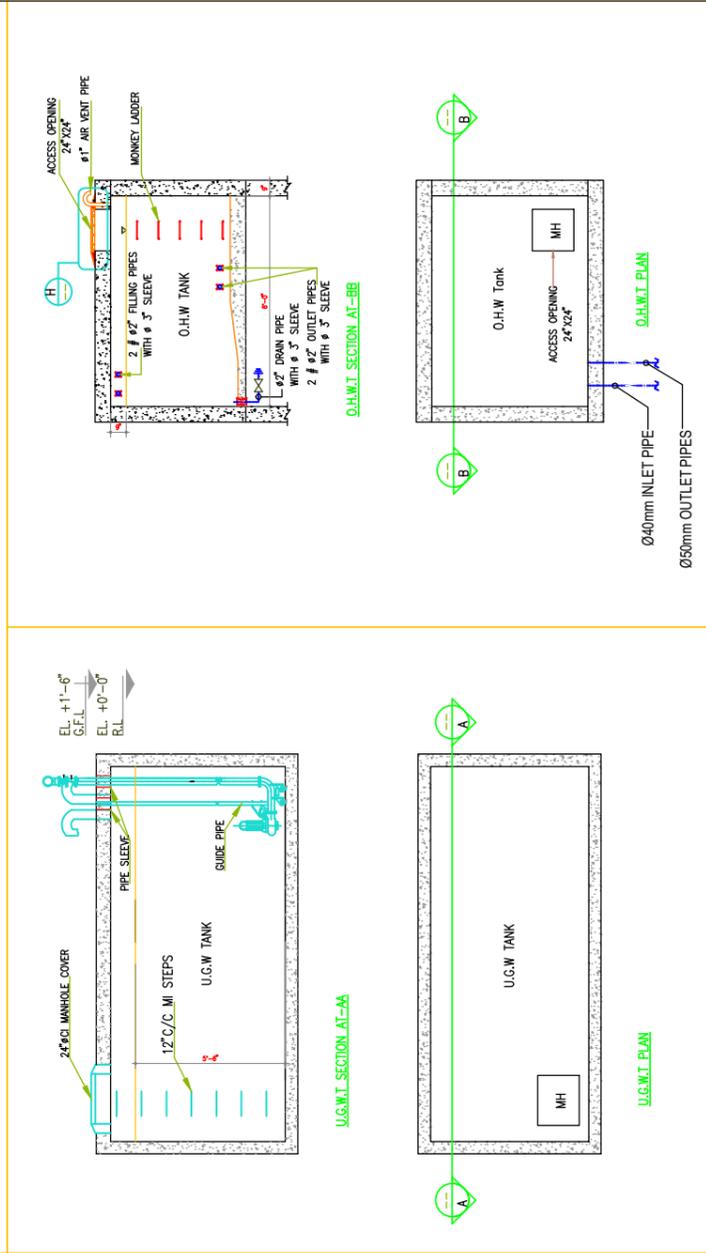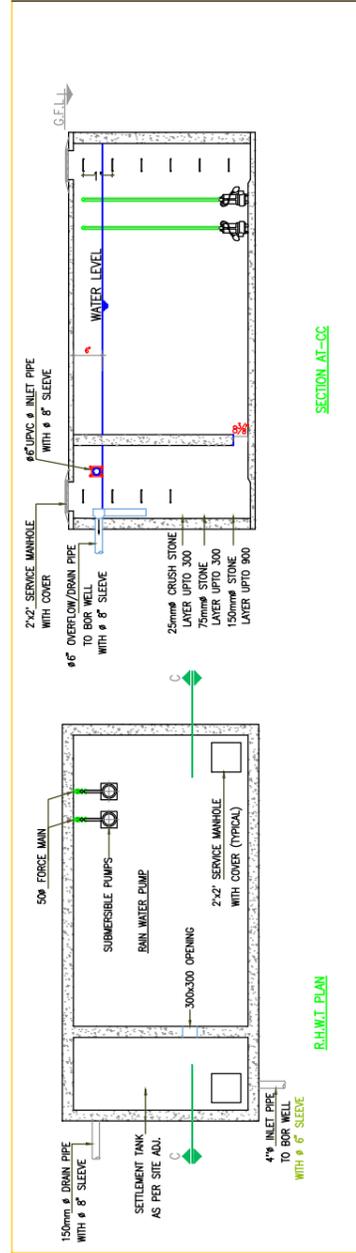

CONSULTANTS :



Phone: 03379225835  
Email: tetrisdesignstudio11@gmail.com

PROJECT:

SCHOOL & SKILL CENTER  
AT  
BAIKER BALOCHISTAN.

CLIENT:

TAALEEM FOUNDATION

TITLE:

TANKS DETAIL & BOUSER  
CONNECTION DETAIL

DRAWN BY:

FARMAN ULLAH

CHECKED BY:

Ar. FARUKH RAZZAQ

SCALE:

N. T. S.


DRAWING NO. P-10

DATE: NOV- 2025








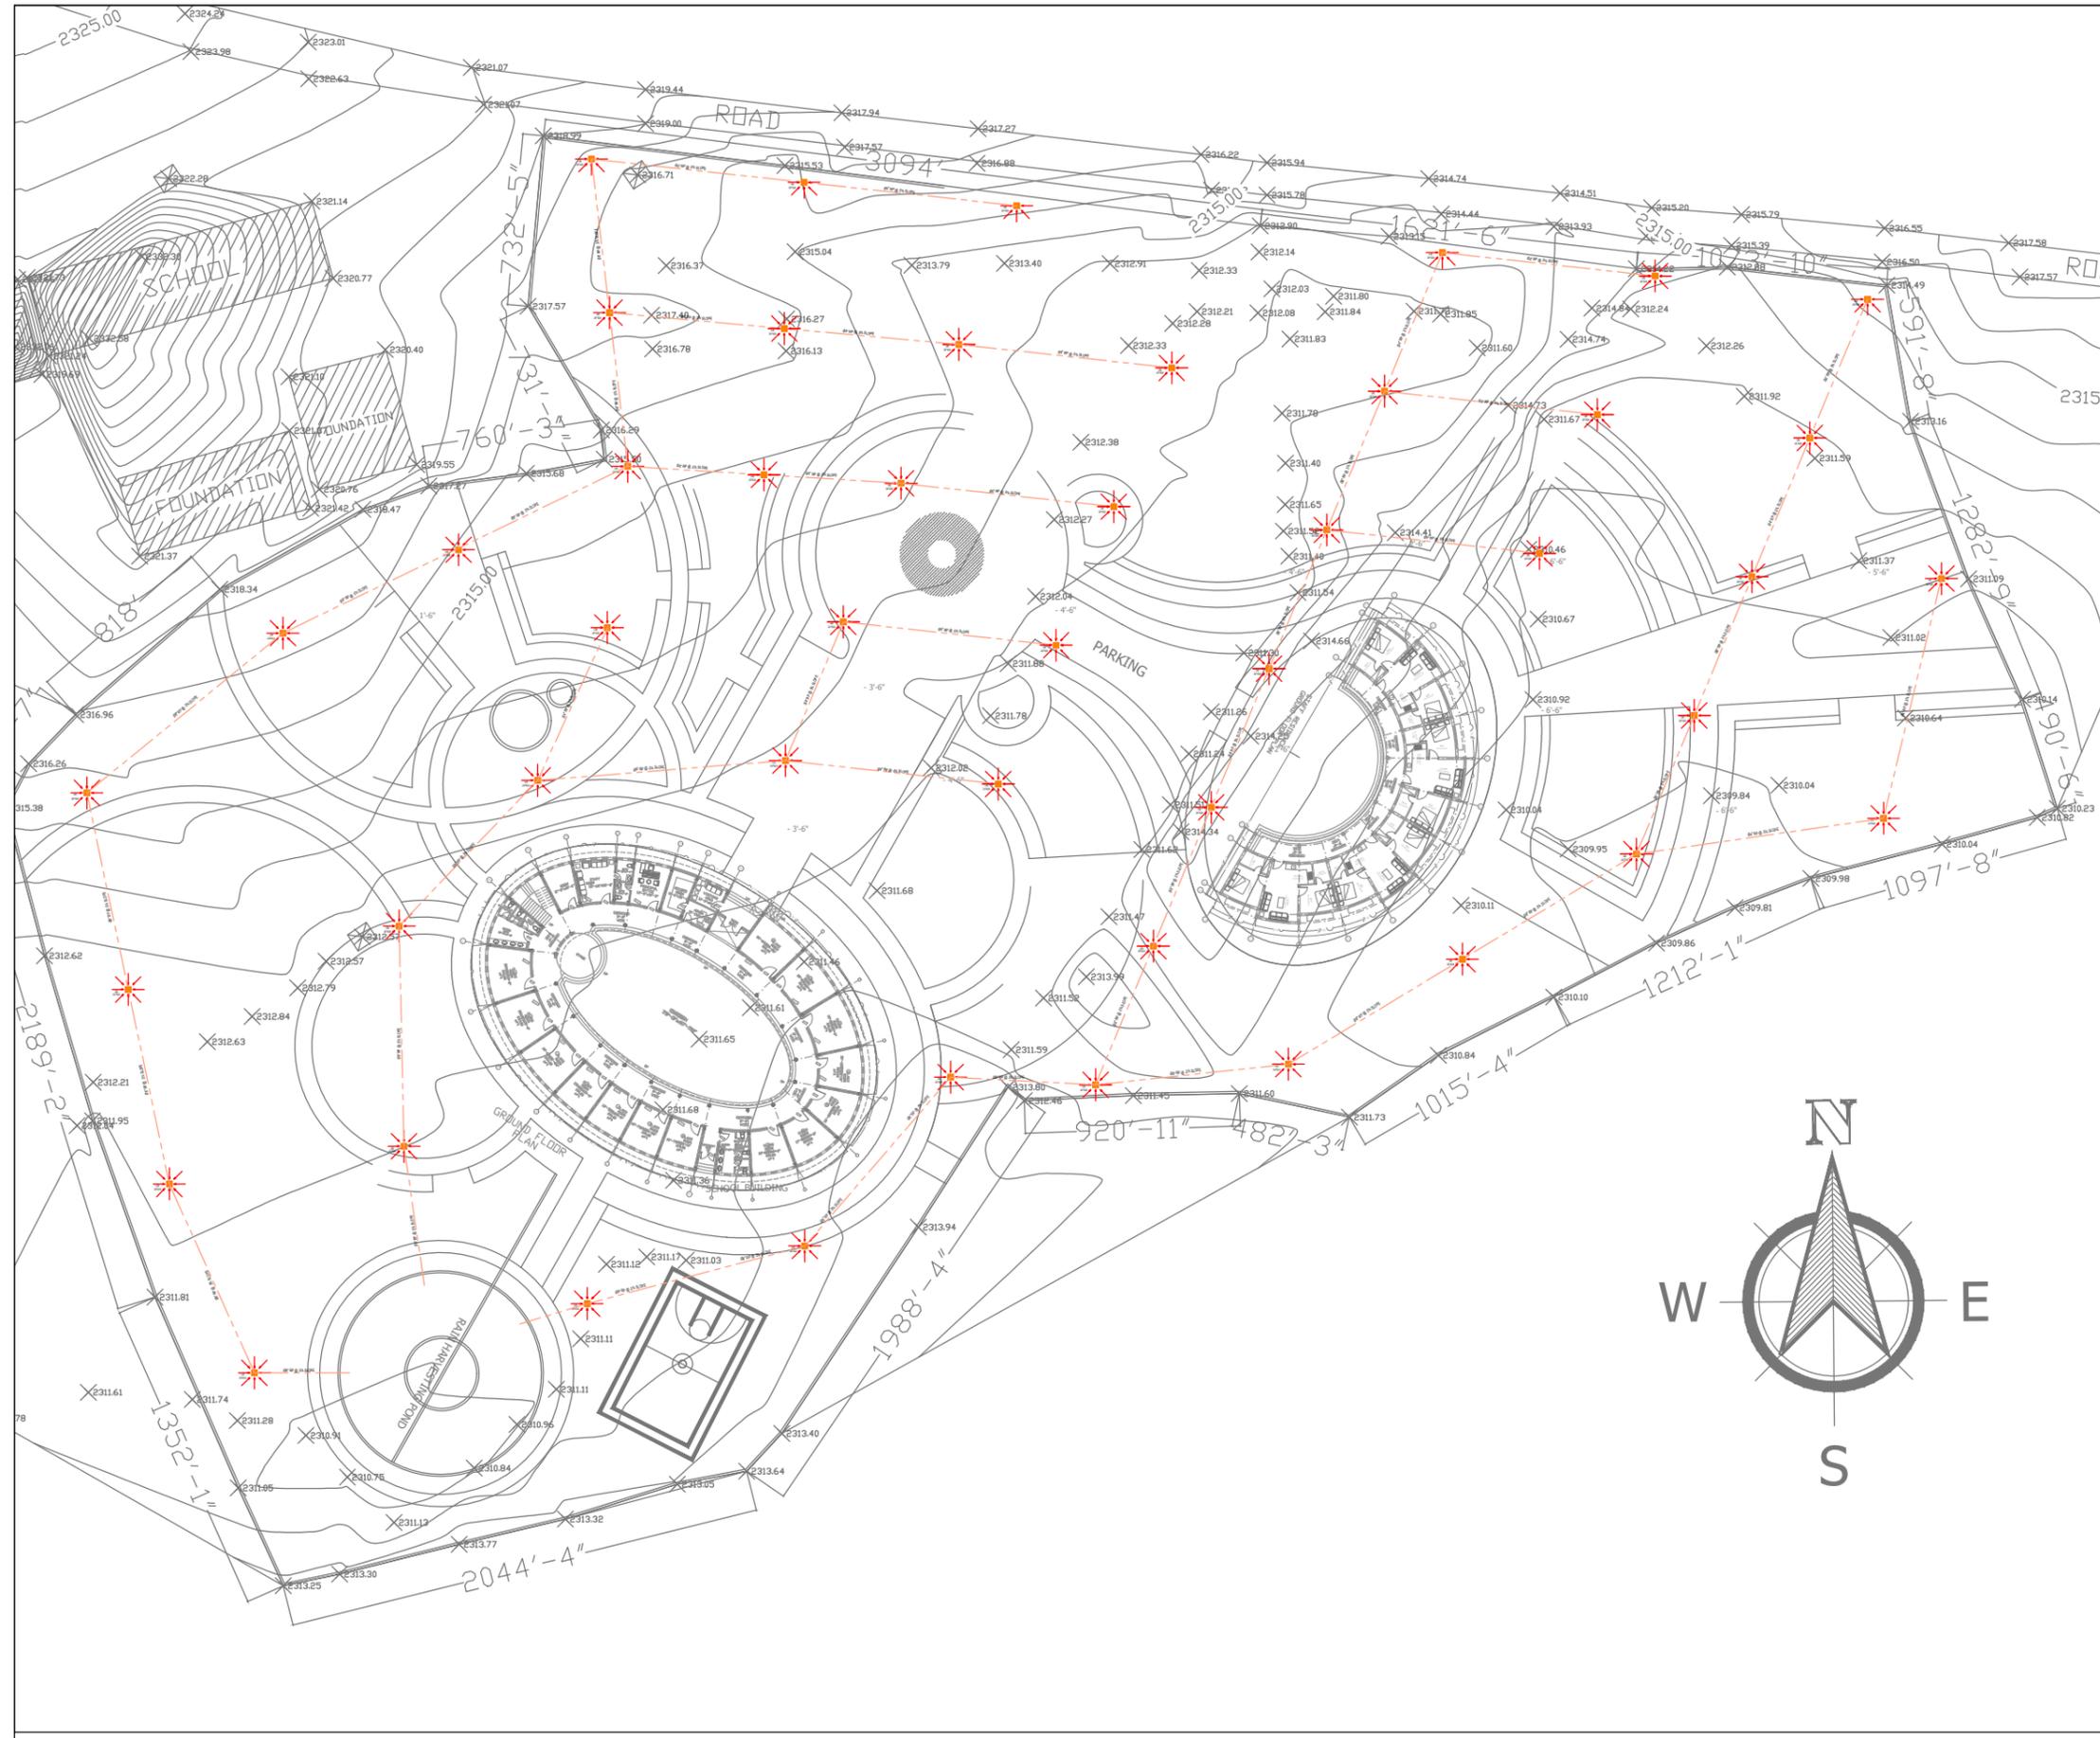

<b>CONSULTANTS :</b>	
 <b>TETR S</b> Design Studio Phone: 03379225835 Email: tetrdesignstudio11@gmail.com	
<b>PROJECT:</b> SCHOOL & SKILL CENTER AT BAIKER BALOCHISTAN.	
<b>CLIENT:</b> TAALEEM FOUNDATION	
<b>TITLE:</b> RAIN WATER MASTER PLAN	
<b>DRAWN BY:</b> FARMAN ULLAH	
<b>CHECKED BY:</b> Ar. FARUKH RAZZAQ	
<b>SCALE:</b> N. T. S.	
<b>DRAWING NO.</b>	P-15
<b>DATE:</b>	NOV- 2025

CONSULTANTS :

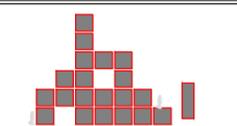

**TETR S**  
Design Studio  
Phone: 03379225835  
Email: tetrisdesignstudio11@gmail.com

PROJECT:

SCHOOL & SKILL CENTER  
AT  
BAIKER BALOCHISTAN.

CLIENT:

TAALEEM FOUNDATION

TITLE:

DRAWN BY:

FARMAN ULLAH

CHECKED BY:

Ar. FARUKH RAZZAQ

SCALE:

N. T. S.

DRAWING NO.

DATE: NOV- 2025

